

City of Somerville IMPROVEMENTS TO LINCOLN PARK

City of Somerville, Massachusetts Joseph A. Curtatone, Mayor

Michael F. Glavin, Executive Director

Mayor's Office of Strategic Planning & Community

Development

Arn Franzen, Director of Parks & Open Space Phone: 617-625-6600

290 Washington Street Somerville, Massachusetts



Locus Map



Washington Street

FEBRUARY 24, 2016
Prepared By



85 Devonshire St, 3rd Floor, Boston, MA 02109 (617) 412-4480 (800) Sampson www.spurrstudio.com







SHEET INDEX

L0.00	. GENERAL NOTES AND LEGENDS
L1.00	EXISTING CONDITIONS PLAN
L1.01	PHASING PLAN
L2.00	SITE PREPARATION AND DEMOLITION PLAN
L3.00	.MATERIALS PLAN
L3.01	MATERIALS ENLARGEMENT PLANS
	. MATERIALS ENLARGEMENT PLANS
	SITE AMENITIES PLAN
L4.00	
L4.01	LAYOUT PLAN ENLARGEMENT
L4.02	LAYOUT PLAN ENLARGEMENT
L5.00	. GRADING PLAN
L5.01	GRADING PLAN ENLARGEMENT
	GRADING PLAN ENLARGEMENT
L5.03	
L6.00	
L7.00	
	PLANTING PLAN ENLARGEMENT
	· PLANTING PLAN ENLARGEMENT
	PLANTING PLAN ENLARGEMENT
. —	· PLANTING PLAN ENLARGEMENT
/ /A\	CONSTRUCTION DETAILS
l1.01	RRIGATION PLAN - WEST
l1.02	RRIGATION PLAN - EAST
l2.01	IRRIGATION DETAILS
l2.02	· IRRIGATION DETAILS
SK-0.0	GENERAL NOTES
SK-1.0	FEATURE PLAN
SK-1.1	METAL MATERIAL PLAN
SK-1.2	CONCRETE MATERIAL PLAN
SK-1.3	JOINTING PLAN
SK-1.4	GRADING PLAN
SK-1.5	CONTROL JOINTS PLAN
SK-1.6	CONTROL LINES PLAN
SK-1.7	CONTROL CURVES PLAN
SK-2.0	SECTIONS & PROFILES
SK-2.1	SECTIONS & PROFILES
SK-3.1	CONSTRUCTION DETAILS
SK-3.2	CONSTRUCTION DETAILS
E0.01	ELECTRICAL LEGEND, GENERAL NOTES AND DETAILS
E1.00	 ELECTRICAL SITE EXISTING CONDITIONS/ DEMOLITION PLAN
E1.01	ELECTRICAL SITE PLAN
E1.02	ELECTRICAL SITE AND BONDING PLAN
E1.03	ELECTRICAL SCHEDULE AND DETAILS

AN I Incom Dark I CONSTRICTION DOOR INTENTS

GENERAL NOTES

- 1. SITE SURVEY CONDUCTED BY GALE ASSOCIATES, WEYMOUTH, MA, ON AUGUST 15, 2012.
- 2. REFER TO EXISTING CONDITIONS FOR SURVEY LEGEND. ANY QUANTITIES SHOWN ON THE PLANS ARE FOR BIDDING PURPOSES ONLY. ALL BIDDERS ARE REQUIRED TO INSPECT THE PROJECT SITE IN ITS ENTIRETY PRIOR TO SUBMITTING THEIR BID, AND BECOME FAMILIAR WITH ALL CONDITIONS AS THEY MAY AFFECT THEIR BID. CONTRACTOR AND SUB-CONTRACTOR SHALL BE FAMILIAR WITH ALL DRAWINGS AND SPECIFICATIONS PRIOR TO COMMENCING THE CONSTRUCTION.
- 3. LOCATIONS OF ANY UTILITIES SHOWN ON THESE PLANS ARE APPROXIMATE ONLY. CONTRACTOR SHALL BE RESPONSIBLE FOR VERIFYING THE LOCATION OF SUCH UTILITIES, PROTECTING ALL EXISTING UTILITIES AND REPAIRING ANY DAMAGE DONE DURING CONSTRUCTION. THE CONTRACTOR SHALL BE RESPONSIBLE FOR ALL ON-SITE COORDINATION WITH UTILITY COMPANIES AND PUBLIC AGENCIES AND FOR OBTAINING ALL REQUIRED PERMITS AND PAYING ALL REQUIRED FEES. IN ACCORDANCE WITH M.G.L. CHAPTER 82, SECTION 40, INCLUDING AMENDMENTS, CONTRACTORS SHALL NOTIFY ALL UTILITY COMPANIES AND GOVERNMENT AGENCIES IN WRITING PRIOR TO EXCAVATION. CONTRACTOR SHALL ALSO CALL "DIG SAFE" AT (888) 344-7233 NO LESS THAN 72 HOURS, (EXCLUSIVE OF WEEKENDS AND HOLIDAYS), PRIOR TO SUCH EXCAVATION. DOCUMENTATION OF REQUESTS SHALL BE PROVIDED TO PROJECT REPRESENTATIVE PRIOR TO EXCAVATION WORK.
- 4. CONTRACTOR SHALL BE RESPONSIBLE FOR REVIEWING ALL DRAWINGS AND SPECIFICATIONS TO DETERMINE THE EXTENT OF EXCAVATION AND DEMOLITION REQUIRED TO RECEIVE SITE IMPROVEMENTS.
- 5. ANY DISCREPANCIES OR CONFLICTS BETWEEN THE DRAWINGS AND EXISTING CONDITIONS, EXISTING CONDITIONS TO REMAIN, TEMPORARY CONSTRUCTION, PERMANENT CONSTRUCTION AND WORK OF ADJACENT CONTRACTS SHALL BE BROUGHT TO THE ATTENTION OF THE OWNERS REPRESENTATIVE BEFORE PROCEEDING. ITEMS ENCOUNTERED IN AREAS OF EXCAVATION THAT ARE NOT INDICATED ON THE DRAWINGS, BUT ARE VISIBLE ON SURFACE, SHALL BE THE CONTRACTOR'S RESPONSIBILITY AND SHALL BE REMOVED AT NO ADDITIONAL COST TO THE OWNER.
- 6. ANY ALTERATIONS TO THESE DRAWINGS MADE IN THE FIELD DURING CONSTRUCTION SHALL BE RECORDED BY THE GENERAL CONTRACTOR ON "AS-BUILT" DRAWINGS.
- 7. ALL AREAS DISTURBED BY THE CONTRACTOR'S OPERATIONS OUTSIDE THE PROJECT LIMITS, SHALL BE RESTORED TO THE ORIGINAL CONDITION BY THE CONTRACTOR AT NO ADDITIONAL COST AND TO THE SATISFACTION OF THE OWNER.
- 8. THE CONTRACTOR SHALL TAKE ALL NECESSARY PRECAUTIONS TO PROTECT HIS EMPLOYEES, AS WELL AS PUBLIC USERS FROM INJURY DURING THE ENTIRE CONSTRUCTION PERIOD USING ALL NECESSARY SAFEGUARDS, INCLUDING BUT NOT LIMITED TO, THE ERECTION OF TEMPORARY WALKS, STRUCTURES, PROTECTIVE BARRIERS, COVERING, OR FENCES AS NEEDED.
- 9. THE CONTRACTOR SHALL SUPPLY THE OWNER WITH THE NAME OF THE OSHA "COMPETENT PERSON" PRIOR TO CONSTRUCTION.
- 10. FILLING OF EXCAVATED AREAS SHALL NOT TAKE PLACE WITHOUT THE PRESENCE OR PERMISSION OF THE OWNER'S REPRESENTATIVE.
- 11. EXISTING TREES TO REMAIN SHALL BE PROTECTED FROM CONSTRUCTION ACTIVITIES. NO STOCKPILING OF MATERIAL, EQUIPMENT OR VEHICULAR TRAFFIC SHALL BE ALLOWED WITHIN THE DRIP LINE OF TREES TO REMAIN. NO GUIDES SHALL BE ATTACHED TO ANY TREE TO REMAIN. WHEN NECESSARY OR AS DIRECTED BY THE OWNER'S REPRESENTATIVE, THE CONTRACTOR SHALL ERECT TEMPORARY BARRIERS FOR THE PROTECTION OF EXISTING TREES DURING CONSTRUCTION.
- 12. NO FILLING SHALL OCCUR AROUND EXISTING TREES TO REMAIN WITHOUT THE APPROVAL OF THE OWNER OR OWNER'S REPRESENTATIVE.
- 13. ALL EXISTING DRAINAGE FACILITIES TO REMAIN SHALL BE MAINTAINED FREE OF DEBRIS, SOIL, SEDIMENT, AND FOREIGN MATERIAL AND OPERATIONAL THROUGHOUT THE LIFE OF THE CONTRACT. REMOVE ALL SOIL, SEDIMENT, DEBRIS AND FOREIGN MATERIAL FROM ALL DRAINAGE STRUCTURES, INCLUDING BUT NOT LIMITED TO, DRAINAGE INLETS, MANHOLES AND CATCH BASINS WITHIN THE LIMIT OF WORK AND DRAINAGE STRUCTURES OUTSIDE THE LIMIT OF WORK THAT ARE IMPACTED BY THE WORK FOR THE ENTIRE DURATION OF CONSTRUCTION.
- 14. CONTRACTOR'S STAGING AREA MUST BE WITHIN THE CONTRACT LIMIT LINE AND IN AREAS APPROVED BY OWNER. ANY OTHER AREAS THAT THE CONTRACTOR MAY WISH TO USE FOR STAGING MUST BE COORDINATED WITH THE OWNER.
- 15. THE CONTRACTOR SHALL KEEP ALL STREETS, PARKING LOTS AND WALKS THAT ARE NOT RESTRICTED FROM PUBLIC USE DURING CONSTRUCTION BROOM CLEAN AT ALL TIMES. THE CONTRACTOR SHALL USE ACCEPTABLE METHODS AND MATERIALS TO MAINTAIN ADEQUATE DUST CONTROL THROUGHOUT CONSTRUCTION.
- 16. CONTRACTOR SHALL COORDINATE ALL WORK WITH THE OWNERS REPRESENTATIVE.
- 17. CONTRACTOR SHALL COORDINATE WITH THE ARGENZIANO SCHOOL ADMINISTRATORS TO ENSURE SCHEDULED WORK, DELIVERABLES, AND VEHICLES OR EQUIPMENT ENTERING AND LEAVING THE SITE DO NOT CONFLICT WITH SCHOOL ACTIVITIES, DROP-OFF/ PICK-UP, AND STAFF/ STUDENT ACCESS.

EROSION AND SEDIMENT CONTROL NOTES

- 1. ALL SEDIMENT AND EROSION CONTROL DEVICES SHALL BE PUT INTO PLACE PRIOR TO BEGINNING ANY CONSTRUCTION OR DEMOLITION. REFER TO SPECIFICATIONS AND DETAILS FOR TYPE OF EROSION AND SEDIMENT CONTROL.
- 2. THE CONTRACTOR SHALL BE RESPONSIBLE FOR THE CONTINUAL MAINTENANCE OF ALL CONTROL DEVICES THROUGHOUT THE DURATION OF THE PROJECT.
- 3. CONTRACTOR SHALL MEET ALL OF THE STATE OF MASSACHUSETTS D.E.P. AND THE CITY OF SOMERVILLE ORDINANCE REGULATIONS FOR SEDIMENT AND EROSION CONTROL.
- 4. EXCAVATED MATERIAL STOCKPILED ON THE SITE SHALL BE SURROUNDED BY A RING OF UNBROKEN SEDIMENT AND EROSION CONTROL FENCE. THE LIMITS OF ALL GRADING AND DISTURBANCE SHALL BE KEPT TO A MINIMUM WITHIN THE APPROVED AREA OF CONSTRUCTION. ALL AREAS OUTSIDE OF THE LIMIT OF CONTRACT SHALL REMAIN TOTALLY UNDISTURBED UNLESS OTHERWISE APPROVED BY OWNER'S REPRESENTATIVE.
- 5. ALL CATCH BASINS AND DRAIN GRATES WITHIN LIMIT OF CONTRACT SHALL BE PROTECTED WITH FILTER FABRIC DURING THE ENTIRE DURATION OF CONSTRUCTION.
- 6. EROSION CONTROL BARRIERS TO BE INSTALLED AT THE TOE OF SLOPES. SEE GRADING & DRAINAGE PLANS, NOTES, DETAILS AND SPECIFICATIONS.
- 7. THE CONTRACTOR SHALL PROVIDE DUST CONTROL FOR CONSTRUCTION OPERATIONS AS APPROVED BY OWNER.
- 8. ALL POINTS OF CONSTRUCTION EGRESS OR INGRESS SHALL BE MAINTAINED TO PREVENT TRACKING OR FLOWING OF SEDIMENT ONTO PUBLIC/PRIVATE ROADS. CONTRACTOR SHALL PROVIDE A WASHOUT AREA ON SITE.

DEMOLITION & SITE PREPARATION NOTES

- 1. THE CONTRACTOR SHALL INCLUDE IN THE BID THE COST OF REMOVING ANY EXISTING SITE FEATURES AND APPURTENANCES NECESSARY TO ACCOMPLISH THE CONSTRUCTION OF THE PROPOSED SITE IMPROVEMENTS. THE CONTRACTOR SHALL ALSO INCLUDE IN THE BID THE COST NECESSARY TO RESTORE SUCH ITEMS IF THEY ARE SCHEDULED TO REMAIN AS PART OF THE FINAL SITE IMPROVEMENTS. REFER TO PLANS TO DETERMINE EXCAVATION, DEMOLITION AND TO DETERMINE THE LOCATION OF THE PROPOSED SITE IMPROVEMENTS.
- 2. THE OWNER RESERVES THE RIGHT TO REVIEW ALL MATERIALS DESIGNATED FOR REMOVAL AND TO RETAIN OWNERSHIP OF SUCH MATERIALS. IF THE OWNER RETAINS ANY MATERIAL THE CONTRACTOR SHALL MAKE ARRANGEMENTS WITH THE OWNER TO HAVE THOSE MATERIALS REMOVED OFF SITE AT NO ADDITIONAL COST.
- 3. UNLESS SPECIFICALLY NOTED TO BE REMOVED AND STOCKPILED (R&S) OR REUSED AND RELOCATED (R&R), ALL SITE FEATURES CALLED TO BE REMOVED AND DEMOLISHED (R&D) SHALL BE REMOVED WITH THEIR FOOTINGS, ATTACHMENTS, BASE MATERIAL, ETC, TRANSPORTED FROM THE SITE TO BE DISPOSED OF IN A LAWFUL MANNER AT AN ACCEPTABLE DISPOSAL SITE AND AT NO COST TO THE OWNER.
- 4. ALL EXISTING SITE FEATURES TO REMAIN SHALL BE PROTECTED THROUGHOUT THE CONSTRUCTION PERIOD. ANY FEATURES DAMAGED DURING CONSTRUCTION OPERATIONS SHALL BE REPAIRED OR REPLACED TO THE SATISFACTION OF THE OWNER'S REPRESENTATIVE AT NO ADDITIONAL COST.
- 5. DURING EARTHWORK OPERATIONS, CONTRACTOR SHALL TAKE CARE TO NOT DISTURB EXISTING MATERIALS TO REMAIN, OUTSIDE THE LIMITS OF EXCAVATION AND BACKFILL AND SHALL TAKE WHATEVER MEASURES NECESSARY, AT THE CONTRACTOR'S EXPENSE, TO PREVENT ANY EXCAVATED MATERIAL FROM COLLAPSING. ALL BACKFILL MATERIALS SHALL BE PLACED AND COMPACTED AS SPECIFIED TO THE SUBGRADE REQUIRED FOR THE INSTALLATION OF THE REMAINDER OF THE CONTRACT WORK.
- 6. IT SHALL BE THE CONTRACTOR'S OPTION, WITH CONCURRENCE OF THE OWNER'S REPRESENTATIVE, TO REUSE EXISTING GRAVEL PAVEMENT BASE COURSE IF IT MEETS THE REQUIREMENTS OF THE SPECIFICATIONS FOR GRAVEL BORROW.
- 7. ALL ITEMS CALLED FOR REMOVAL SHALL BE REMOVED TO FULL DEPTH INCLUDING ALL FOOTINGS, FOUNDATIONS, AND OTHER APPURTENANCES, EXCEPT AS SPECIFICALLY NOTED OTHERWISE.
- 8. STRIP & STORE EXISTING TOPSOIL FOR LATER REUSE AS INDICATED ON PLANS WITH APPROPRIATE EROSION AND SEDIMENT CONTROLS. THE CONTRACTOR SHALL CONFIRM THAT THE SOIL IS SUITABLE FOR REUSE.
- 9. LOAM BORROW/ TOPSOIL DESIGNATED FOR REUSE AS GENERAL FILL SHALL BE BLENDED WITH SUITABLE BORROW MATERIAL AS SPECIFIED.
- 10. TREES DESIGNATED FOR REMOVAL SHALL BE TAGGED BY CONTRACTOR AND APPROVED BY OWNER'S REPRESENTATIVE PRIOR TO COMMENCEMENT OF CONSTRUCTION.
- 11. THE CONTRACTOR SHALL PROTECT EXISTING TREES TO REMAIN. CONTRACTOR SHALL INSTALL TREE PROTECTION BARRIER AFTER CLEARING UNDERBRUSH BY HAND AND TAKE DUE CARE TO PREVENT INJURY TO TREES DURING CLEARING OPERATIONS.
- 12. THE STORAGE OF MATERIALS AND EQUIPMENT WILL BE PERMITTED AT LOCATIONS DESIGNATED BY OWNER OR OWNER'S REPRESENTATIVE. PROTECTION OF STORED MATERIALS AND EQUIPMENT SHALL BE THE SOLE RESPONSIBILITY OF THE CONTRACTOR.

LAYOUT & MATERIALS NOTES

- 1. REFER TO EXISTING CONDITIONS PLANS FOR SURVEY INFORMATION (SHEET L1.00).
- COORDINATE ALL LAYOUT ACTIVITIES WITH THE SCOPE OF WORK CALLED FOR BY DEMOLITION, GRADING AND UTILITIES OPERATIONS ENCOMPASSED BY THIS CONTRACT. SET, PROTECT AND REPLACE REFERENCE STAKES AS NECESSARY OR AS REQUIRED BY THE OWNER'S REPRESENTATIVE.
- 3. ALL WORK SHALL BE PREFORMED BY CONTRACTOR UNLESS SPECIFICALLY INDICATED THAT THE WORK WILL BE PREFORMED "BY CITY".
- 4. ALL LAYOUT LINES, OFFSETS, OR REFERENCES TO LOCATING OBJECTS ARE EITHER PARALLEL OR PERPENDICULAR UNLESS OTHERWISE DESIGNATED WITH ANGLE OFFSETS NOTED.
- 5. ALL PROPOSED SITE FEATURES SHALL BE LAID OUT AND STAKED FOR REVIEW AND APPROVAL BY THE OWNER'S REPRESENTATIVE PRIOR TO COMMENCEMENT OF INSTALLATION. ANY REQUIRED ADJUSTMENTS TO THE LAYOUT SHALL BE UNDERTAKEN AS DIRECTED, AT NO ADDITIONAL COST TO THE OWNER.
- 6. ALL PROPOSED PAVEMENTS SHALL MEET THE LINE AND GRADE OF EXISTING ADJACENT PAVEMENT SURFACES. ALL PATHWAY WIDTHS SHALL BE AS NOTED ON THE LAYOUT AND MATERIALS PLAN.
- 7. THE CONTRACTOR SHALL VERIFY ALL DIMENSIONS AND GRADES ON THE GROUND AND REPORT ANY DISCREPANCIES IMMEDIATELY TO THE OWNER'S REPRESENTATIVE.
- 8. THE CONTRACTOR SHALL BE RESPONSIBLE FOR FIELD MEASUREMENT OF ALL PROPOSED FENCES, GATES, AND RAILINGS.
- THE DEPTH OF LOAM BORROW FOR ALL PROPOSED LAWN AREAS SHALL BE 4" MINIMUM.
 ALL DISTURBED AREAS SHALL BE RESTORED WITH LOAM AND SEED UNLESS OTHERWISE NOTED
- 10. ALL REFERENCES TO LOAM AND SEED (L&S) REFER TO HYDROMULCH SEEDED LAWN. SEE HYDROMULCH SEED SPECIFICATION.

GRADING & DRAINAGE NOTES

- ALL WORK RELATING TO INSTALLATION, RENOVATION OR MODIFICATION OF WATER, DRAINAGE AND/OR SEWER SERVICES SHALL BE PERFORMED IN ACCORDANCE WITH THE STANDARDS OF THE CITY OF SOMERVILLE.
- 2. THE CONTRACTOR SHALL VERIFY ALL GRADES ON THE GROUND AND REPORT ANY DISCREPANCIES IMMEDIATELY TO THE OWNER'S REPRESENTATIVE.
- 3. ALL GRADING IS TO BE SMOOTH AND CONTINUOUS WHERE PROPOSED SURFACE MEETS EXISTING SURFACE, BLEND THE TWO PAVEMENTS AND ELIMINATE ROUGH SPOTS AND ABRUPT GRADE CHANGES AND MEET LINE AND GRADE OF EXISTING CONDITIONS WITH NEW IMPROVEMENTS.
- 4. CONTRACTOR SHALL MAINTAIN POSITIVE DRAINAGE AWAY FROM ALL BUILDING FOUNDATIONS AND ENTRANCES.
- 5. CONTRACTOR SHALL ENSURE ALL AREAS ARE PROPERLY PITCH TO DRAIN, WITH NO SURFACE WATER PONDING OR PUDDLING.
- 6. ALL NEW WALKWAYS / ACCESS PATHS MUST CONFORM TO CURRENT AMERICANS WITH DISABILITIES ACT (ADA), AND MASSACHUSETTS ARCHITECTURAL ACCESS BOARD (MAAB) REGULATIONS: WALKWAYS SHALL MAINTAIN A CROSS PITCH OF NOT MORE THAN ONE AND A HALF (1.5%) PERCENT AND THE RUNNING SLOPE (PARALLEL TO THE DIRECTION OF TRAVEL) BETWEEN 1% MIN. AND 4.5% MAX. ANY DISCREPANCIES NOT ALLOWING THIS TO OCCUR SHALL BE REPORTED TO THE OWNERS REPRESENTATIVE PRIOR TO CONTINUING
- 7. ALL UTILITY GRATES, COVERS OR OTHER SURFACE ELEMENTS INTENDED TO BE EXPOSED AT GRADE SHALL BE FLUSH WITH THE ADJACENT FINISHED GRADE AND ADJUSTED TO PROVIDE A SMOOTH TRANSITION AT ALL EDGES.
- 8. THE CONTRACTOR SHALL SET SUBGRADE ELEVATIONS TO ALLOW FOR POSITIVE DRAINAGE AND PROVIDE EROSION CONTROL DEVICES, STRUCTURES, MATERIALS AND CONSTRUCTION METHODS TO DIRECT SILT MIGRATION AWAY FROM DRAINAGE AND OTHER UTILITY SYSTEMS, PUBLIC/PRIVATE STREETS AND WORK AREAS. CLEAN BASINS REGULARLY AND AT THE END OF THE PROJECT.
- 9. EXCAVATION REQUIRED WITHIN PROXIMITY OF KNOWN EXISTING UTILITY LINES SHALL BE DONE BY HAND. CONTRACTOR SHALL REPAIR ANY DAMAGE TO EXISTING UTILITY LINES OR STRUCTURES INCURRED DURING CONSTRUCTION OPERATIONS AT NO COST TO THE OWNER.
- 10. WHERE NEW EARTHWORK MEETS EXISTING EARTHWORK, CONTRACTOR SHALL BLEND NEW EARTHWORK SMOOTHLY INTO EXISTING, PROVIDING VERTICAL CURVES OR ROUNDS AT ALL TOP AND BOTTOM OF SLOPES.
- 11. WHERE A SPECIFIC LIMIT OF WORK LINE IS NOT OBVIOUS OR IMPLIED, BLEND GRADES TO EXISTING CONDITIONS WITHIN 5 FEET OF PROPOSED CONTOURS.
- 12. RESTORE ALL DISTURBED AREAS AND LIMITS OF ALL REMOVALS TO LOAM AND SEED (L&S) UNLESS OTHERWISE NOTED.
- 13. SEE EARTHWORK SECTION OF SPECIFICATIONS FOR EXCAVATION AND FILLING PROCEDURES.

PLANTING NOTES

GENERAL

- COORDINATE ALL PLANTING ACTIVITIES WITH THE SCOPE OF WORK CALLED FOR BY DEMOLITION, GRADING AND UTILITIES PLANS ENCOMPASSED BY THIS CONTRACT. SET, PROTECT AND REPLACE REFERENCE STAKES AS NECESSARY OR AS DIRECTED BY THE OWNER'S REPRESENTATIVE.
- 2. ALL PLANT MATERIAL WILL NEED TO BE TAGGED AND APPROVED BY THE OWNER'S REPRESENTATIVE PRIOR TO INSTALLATION.
- 3. THE CONTRACTOR SHALL IDENTIFY PROPOSED TREE LOCATIONS PRIOR TO PLACEMENT WITH A STAKE AND COORDINATE WITH THE OWNER'S REPRESENTATIVE TO MAKE ANY NECESSARY ADJUSTMENTS BEFORE ACTUAL PLACEMENT. THE CONTRACTOR SHALL NOT PLACE NEW TREES DIRECTLY UNDER OVERHEAD WIRES OR ABOVE UTILITY LINES.
- 4. ALL EXISTING TREES TO REMAIN AND BE PROTECTED ARE TO BE PRUNED FOR CROWN CLEANING AND DEADWOOD REMOVAL.
- 5. PLANT LOCATIONS SHOWN ON THIS PLAN ARE APPROXIMATE ONLY AND SHALL BE APPROVED IN THE FIELD BY THE OWNER'S REPRESENTATIVE PRIOR TO INSTALLATION.
- 6. IF NECESSARY THE CONTRACTOR SHALL MAINTAIN TEMPORARY EROSION CONTROL BLANKET DURING GROUND COVER APPLICATION UNTIL AREAS ARE ESTABLISHED.
- 7. GROUNDCOVER ARE TO BE EQUALLY SPACED WITHIN PLANTING BED AREA. REFER TO PLANT SCHEDULE FOR SPACING.
- 8. THE DEPTH OF LOAM BORROW FOR ALL PROPOSED LAWN AREAS SHALL BE 6" MINIMUM. ALL DISTURBED AREAS SHALL BE RESTORED WITH LOAM AND SEED UNLESS OTHERWISE NOTED

UTILITIES

9. ALL REFERENCES TO LOAM AND SEED REFER TO SECTION 32 92 19 HYDROMULCH IN THE SPECIFICATIONS

ABBREVIATIONS

<u>OLIVEIX</u>	7 1		
PROP	PROPOSED	GICI	GUTTER INLET W/ CURB INLET
ADJ	ADJUST	CBCI	CATCH BASIN W/ CURB INLET
BIT. CONC.	BITUMINOUS CONCRETE	СВ	CATCH BASIN
CEM. CONC.	CEMENT CONCRETE	C.I.T.	CHANGE IN TYPE
В	BASELINE	F&G	FRAME AND GRATE
N.T.S.	NOT TO SCALE	F&C	FRAME AND COVER
B.M.	BENCH MARK	CI	CURB INLET
ABAN	ABANDON	CIP	CAST IRON PIPE
GRAN. CURB	GRANITE CURB	CMP	CORRUGATED METAL PIPE
EXIST. (OR EX.)	EXISTING	DI	DUCTILE IRON PIPE
FDN	FOUNDATION	GI	GUTTER INLET
F.L. (OR F)	FLOW LINE	HYD	HYDRANT
Р	PROPERTY LINE	INV.	INVERT ELEVATION
PVMT	PAVEMENT	UP	UTILITY POLE
RC	REINFORCED CONCRETE	SMH	SEWER MANHOLE
REM	REMOVE	WG	WATER GATE
RET	RETAIN	DS	DOWN SPOUT
R.O.W.	RIGHT-OF-WAY	HDPE	HIGH DENSITY POLYETHYLENE PIPE
R&R	REMOVE AND RELOCATE	PVC	POLYVINYL CHLORIDE
R,R&R	REMOVE, RELOCATED AND RESET	RCP	REINFORCED CONCRETE PIPE
R&S	REMOVE AND STOCKPILE	DMH	DRAIN MANHOLE
R&D	REMOVE AND DISPOSE	LB	LEACHING BASIN
SB	STONE BOUND	CI	CAST IRON
NIC	NOT IN CONTRACT	OCS	OUTLET CONTROL STRUCTURE
H.C.	HANDICAP	OGT	OIL AND GRIT TRAP
WCR	WHEELCHAIR RAMP	VC	VITRIFIED CLAY PIPE
HMA	HOT MIX ASPHALT	LP	LIGHT POLE
G.C.	GENERAL CONTRACTOR	SWTU	STORM WATER TREATMENT UNIT
E.C.	ELECTRICAL CONTRACTOR	HH	HANDHOLE
P.C.	PLUMBING CONTRACTOR		

CITY OF SOMERVILLE



LINCOLN PARK 290 Washington Street Somerville, MA 02143



85 Devonshire Street, 3rd Floor Boston, MA 02109 (617) 412-4480 (800) Sampson www.westonandsampson.com

Consultants:

Veston&Samuson.





rvorur.

Revisions:

Rev Date Description

1 03/07/16 ADDENDUM #1

Seal:



CONSTRUCTION DOCUMENTS

Date: 02.24.2016

Scale: AS SHOWN

Drawn By: CCC/EJA/MBB

CFR

Reviewed By:

Checked By:


Approved By:


Drawing Title:

GENERAL NOTES AND LEGENDS

Sheet Number:

L0.00

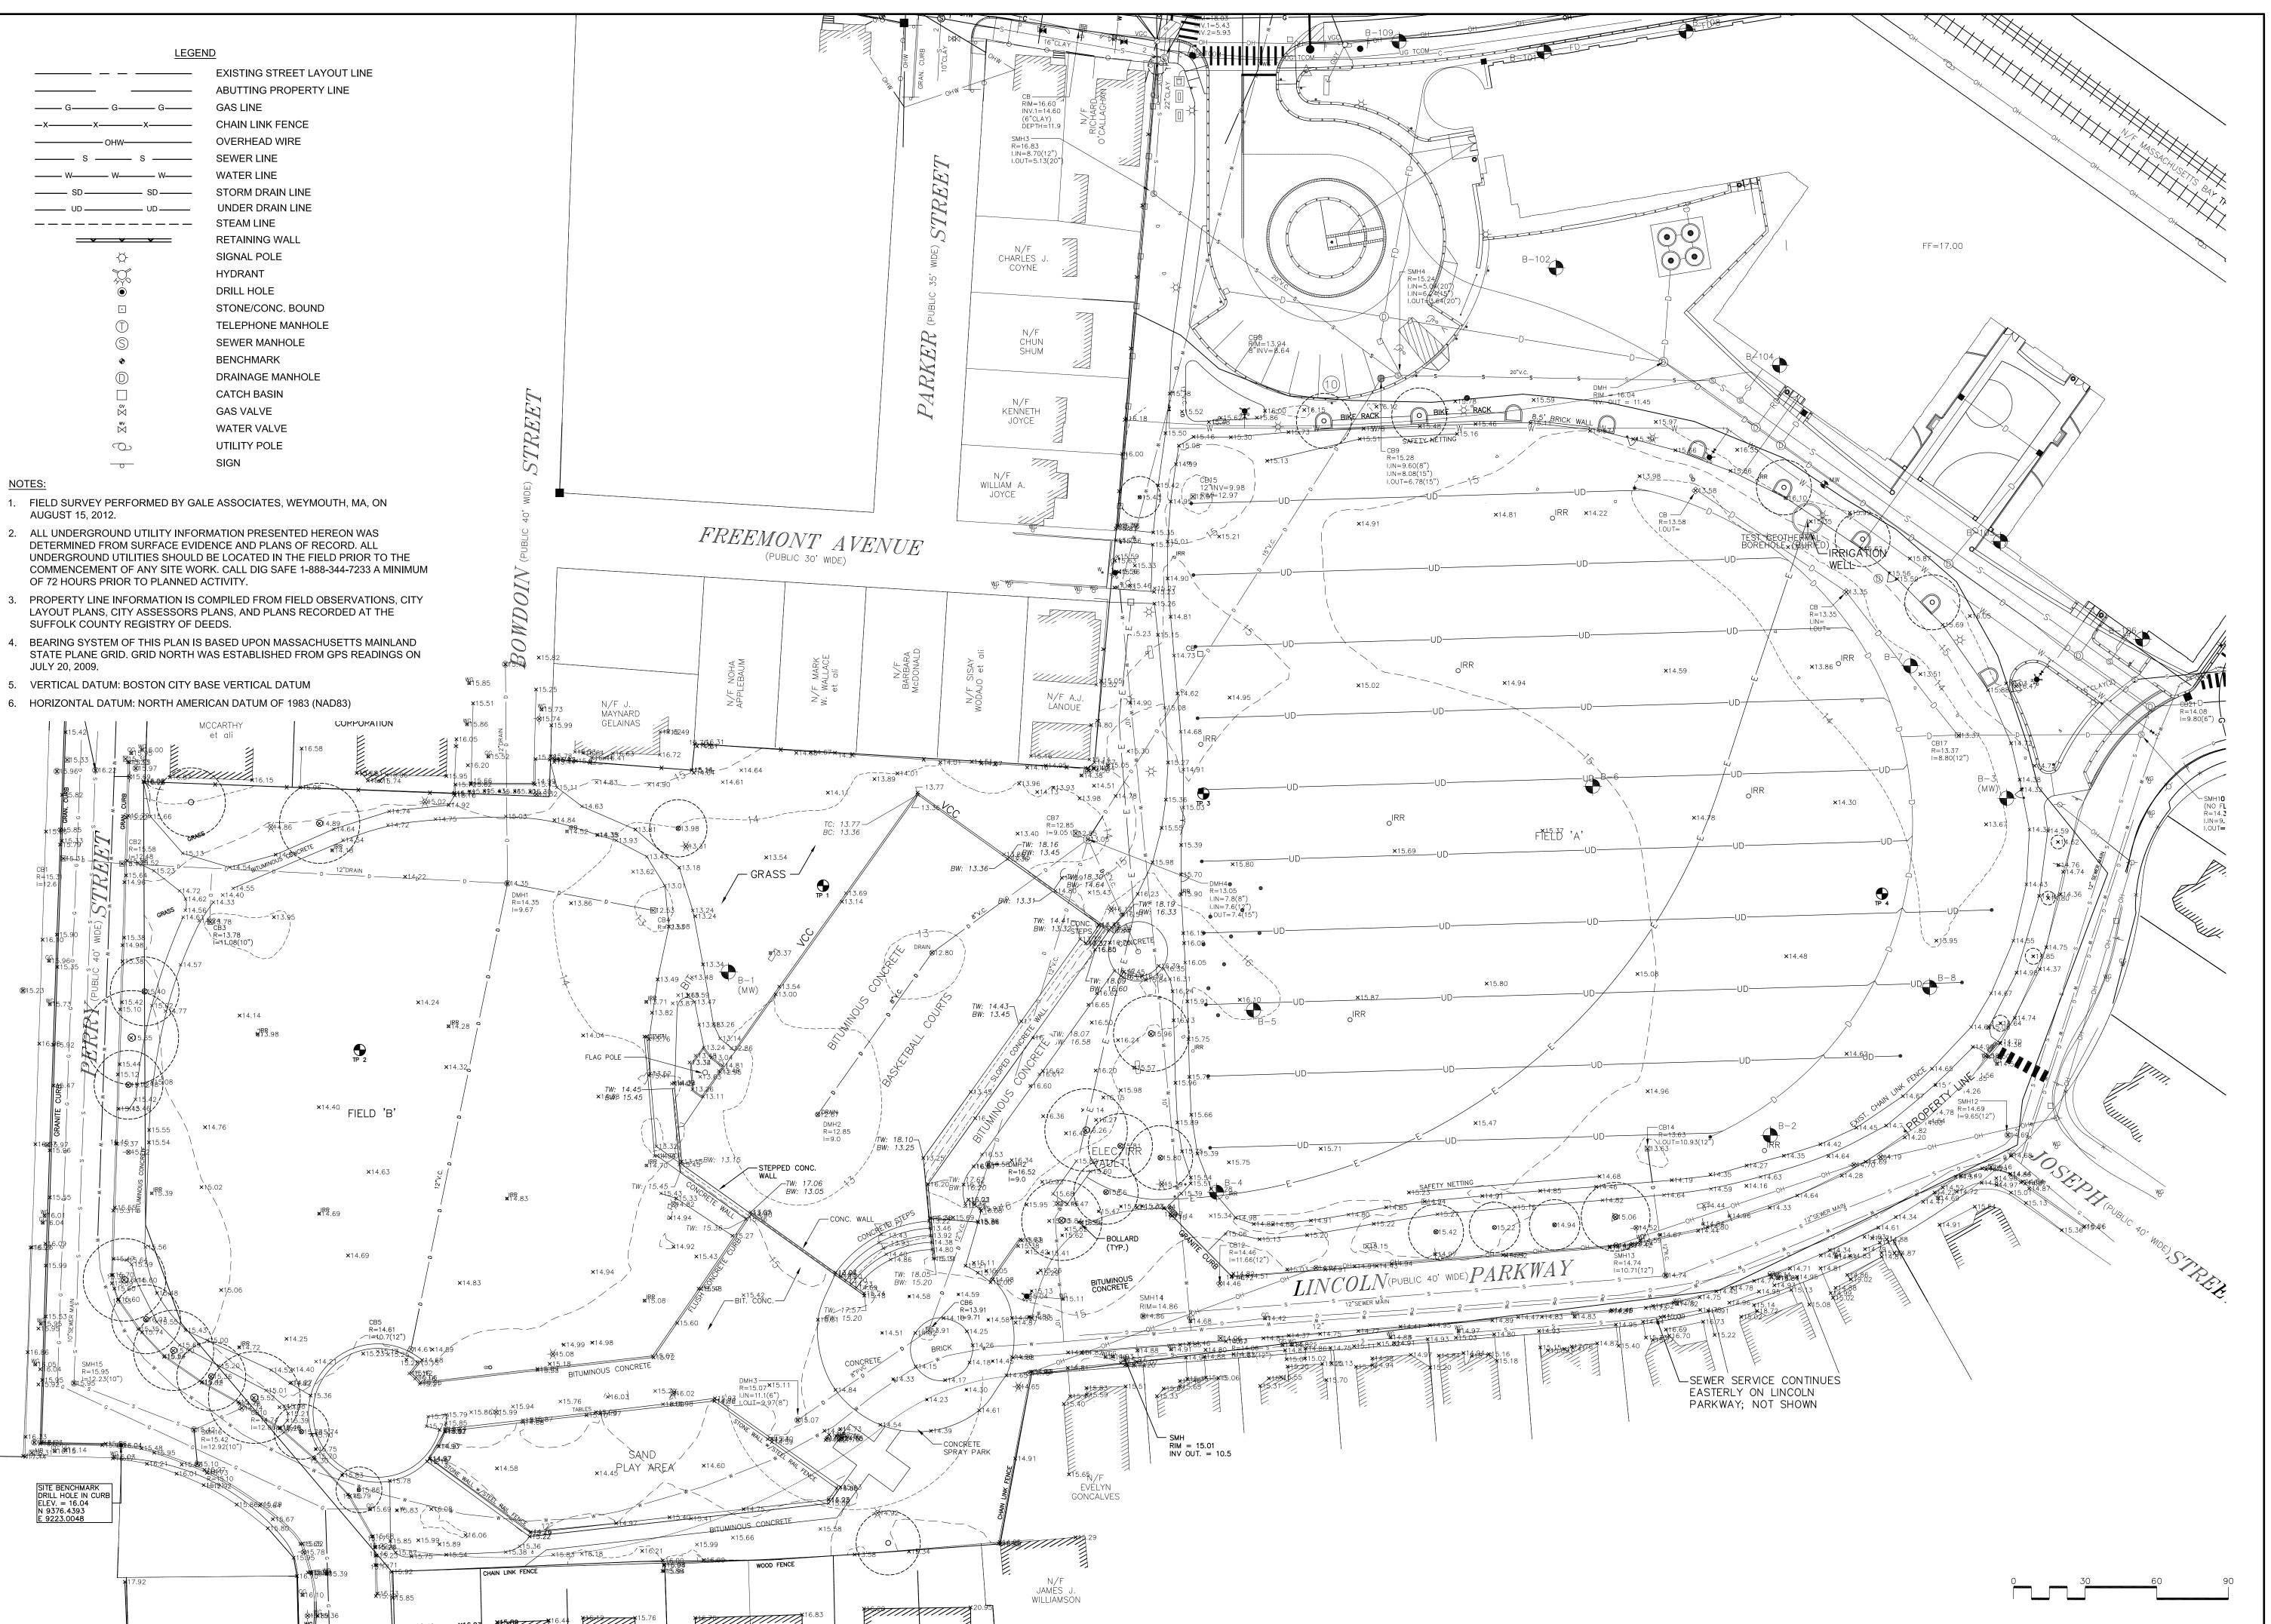


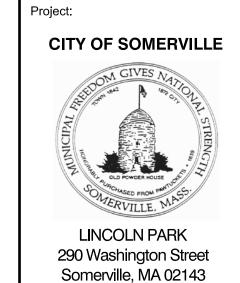




Consultants: Westorsampson®



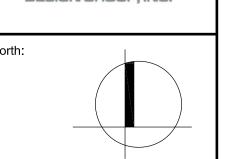

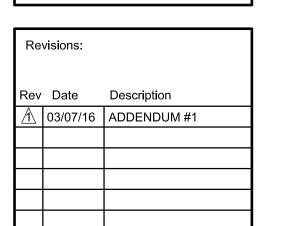



CONSTRUCTION DOCUMENTS

ate: 02.24.2016

cale: AS SHOWN

rawn By: CCC/EJA/MBE

Checked By:


Approved By: CFR


roved By:

Drawing Title:

EXISTING CONDITIONS PLAN

Sheet Number: **L 1 _ O (**

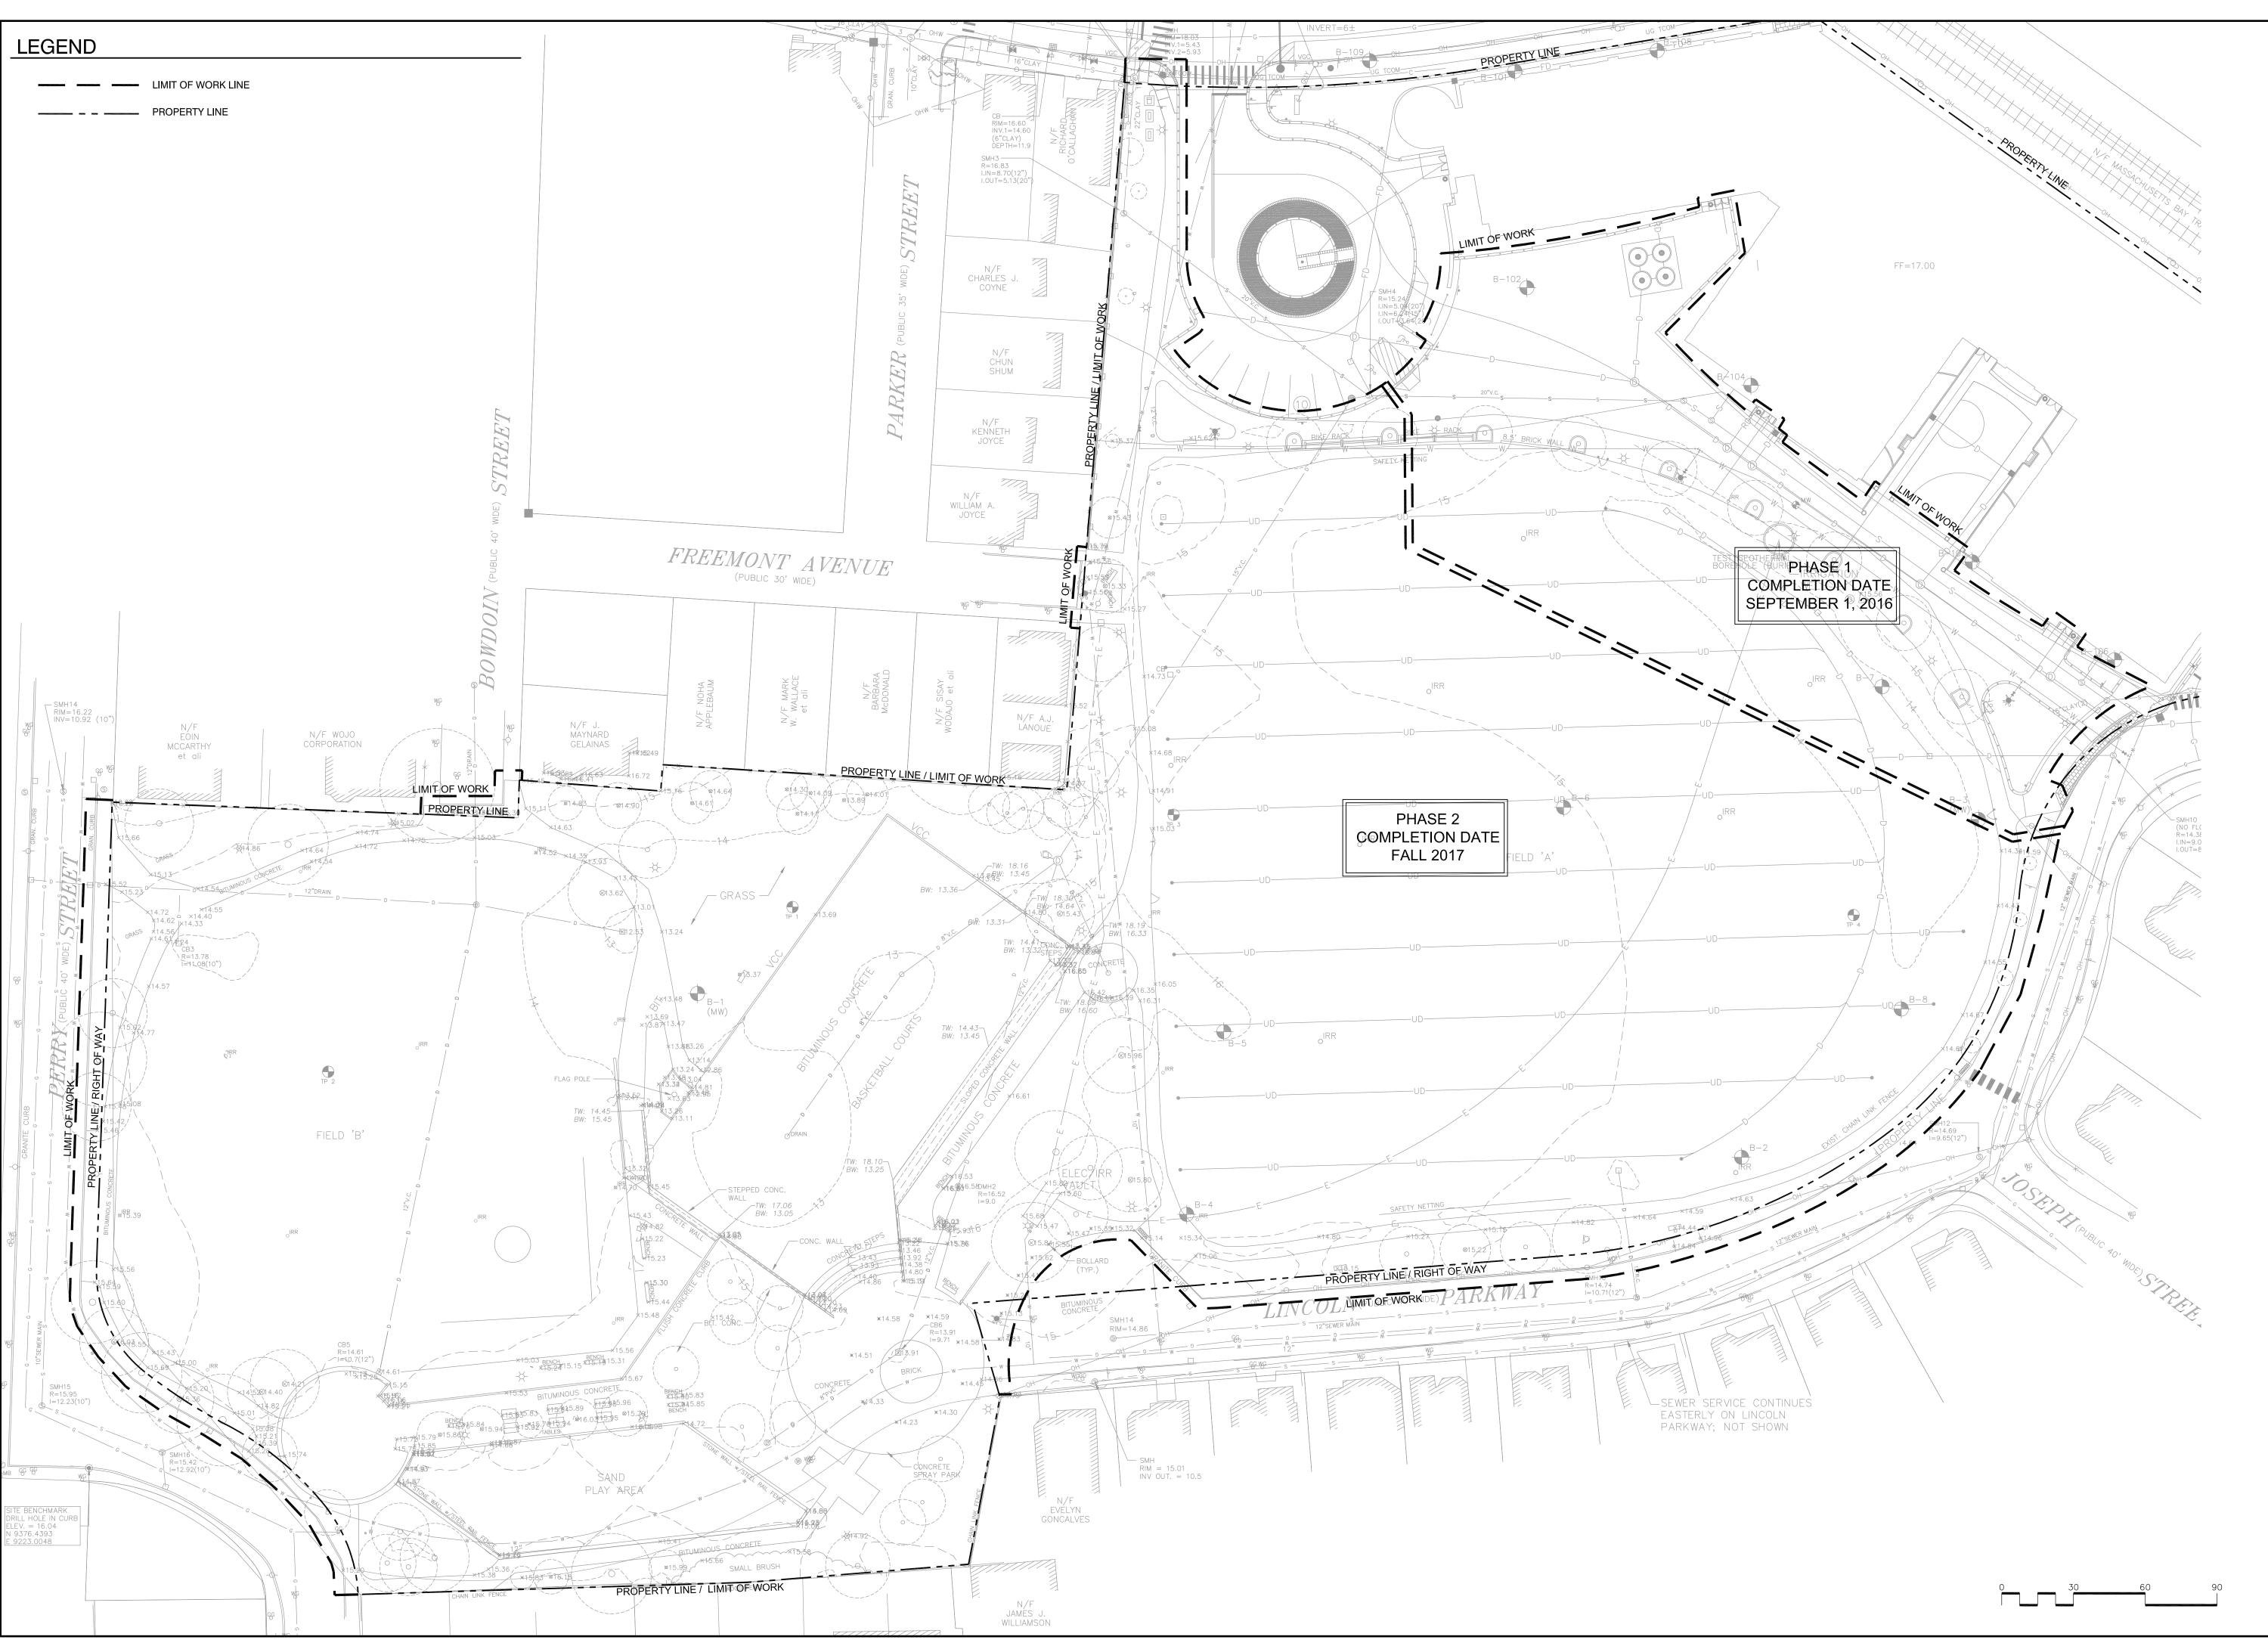

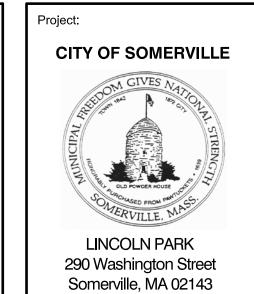




Consultants:





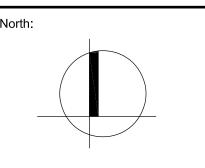

Re	Revisions:		
Rev	/ Date	Description	
\triangle	03/07/16	ADDENDUM #1	
-			

Seal:



CONSTRUCTION DOCUMENTS

Date: 02.24.2016

Scale: AS SHOWN

Drawn By: CCC/EJA/MBE

Reviewed By: BMK

Checked By:

Approved By:


CFR


Drawing Title:

PHASING PLAN

Sheet Number:

L1.01

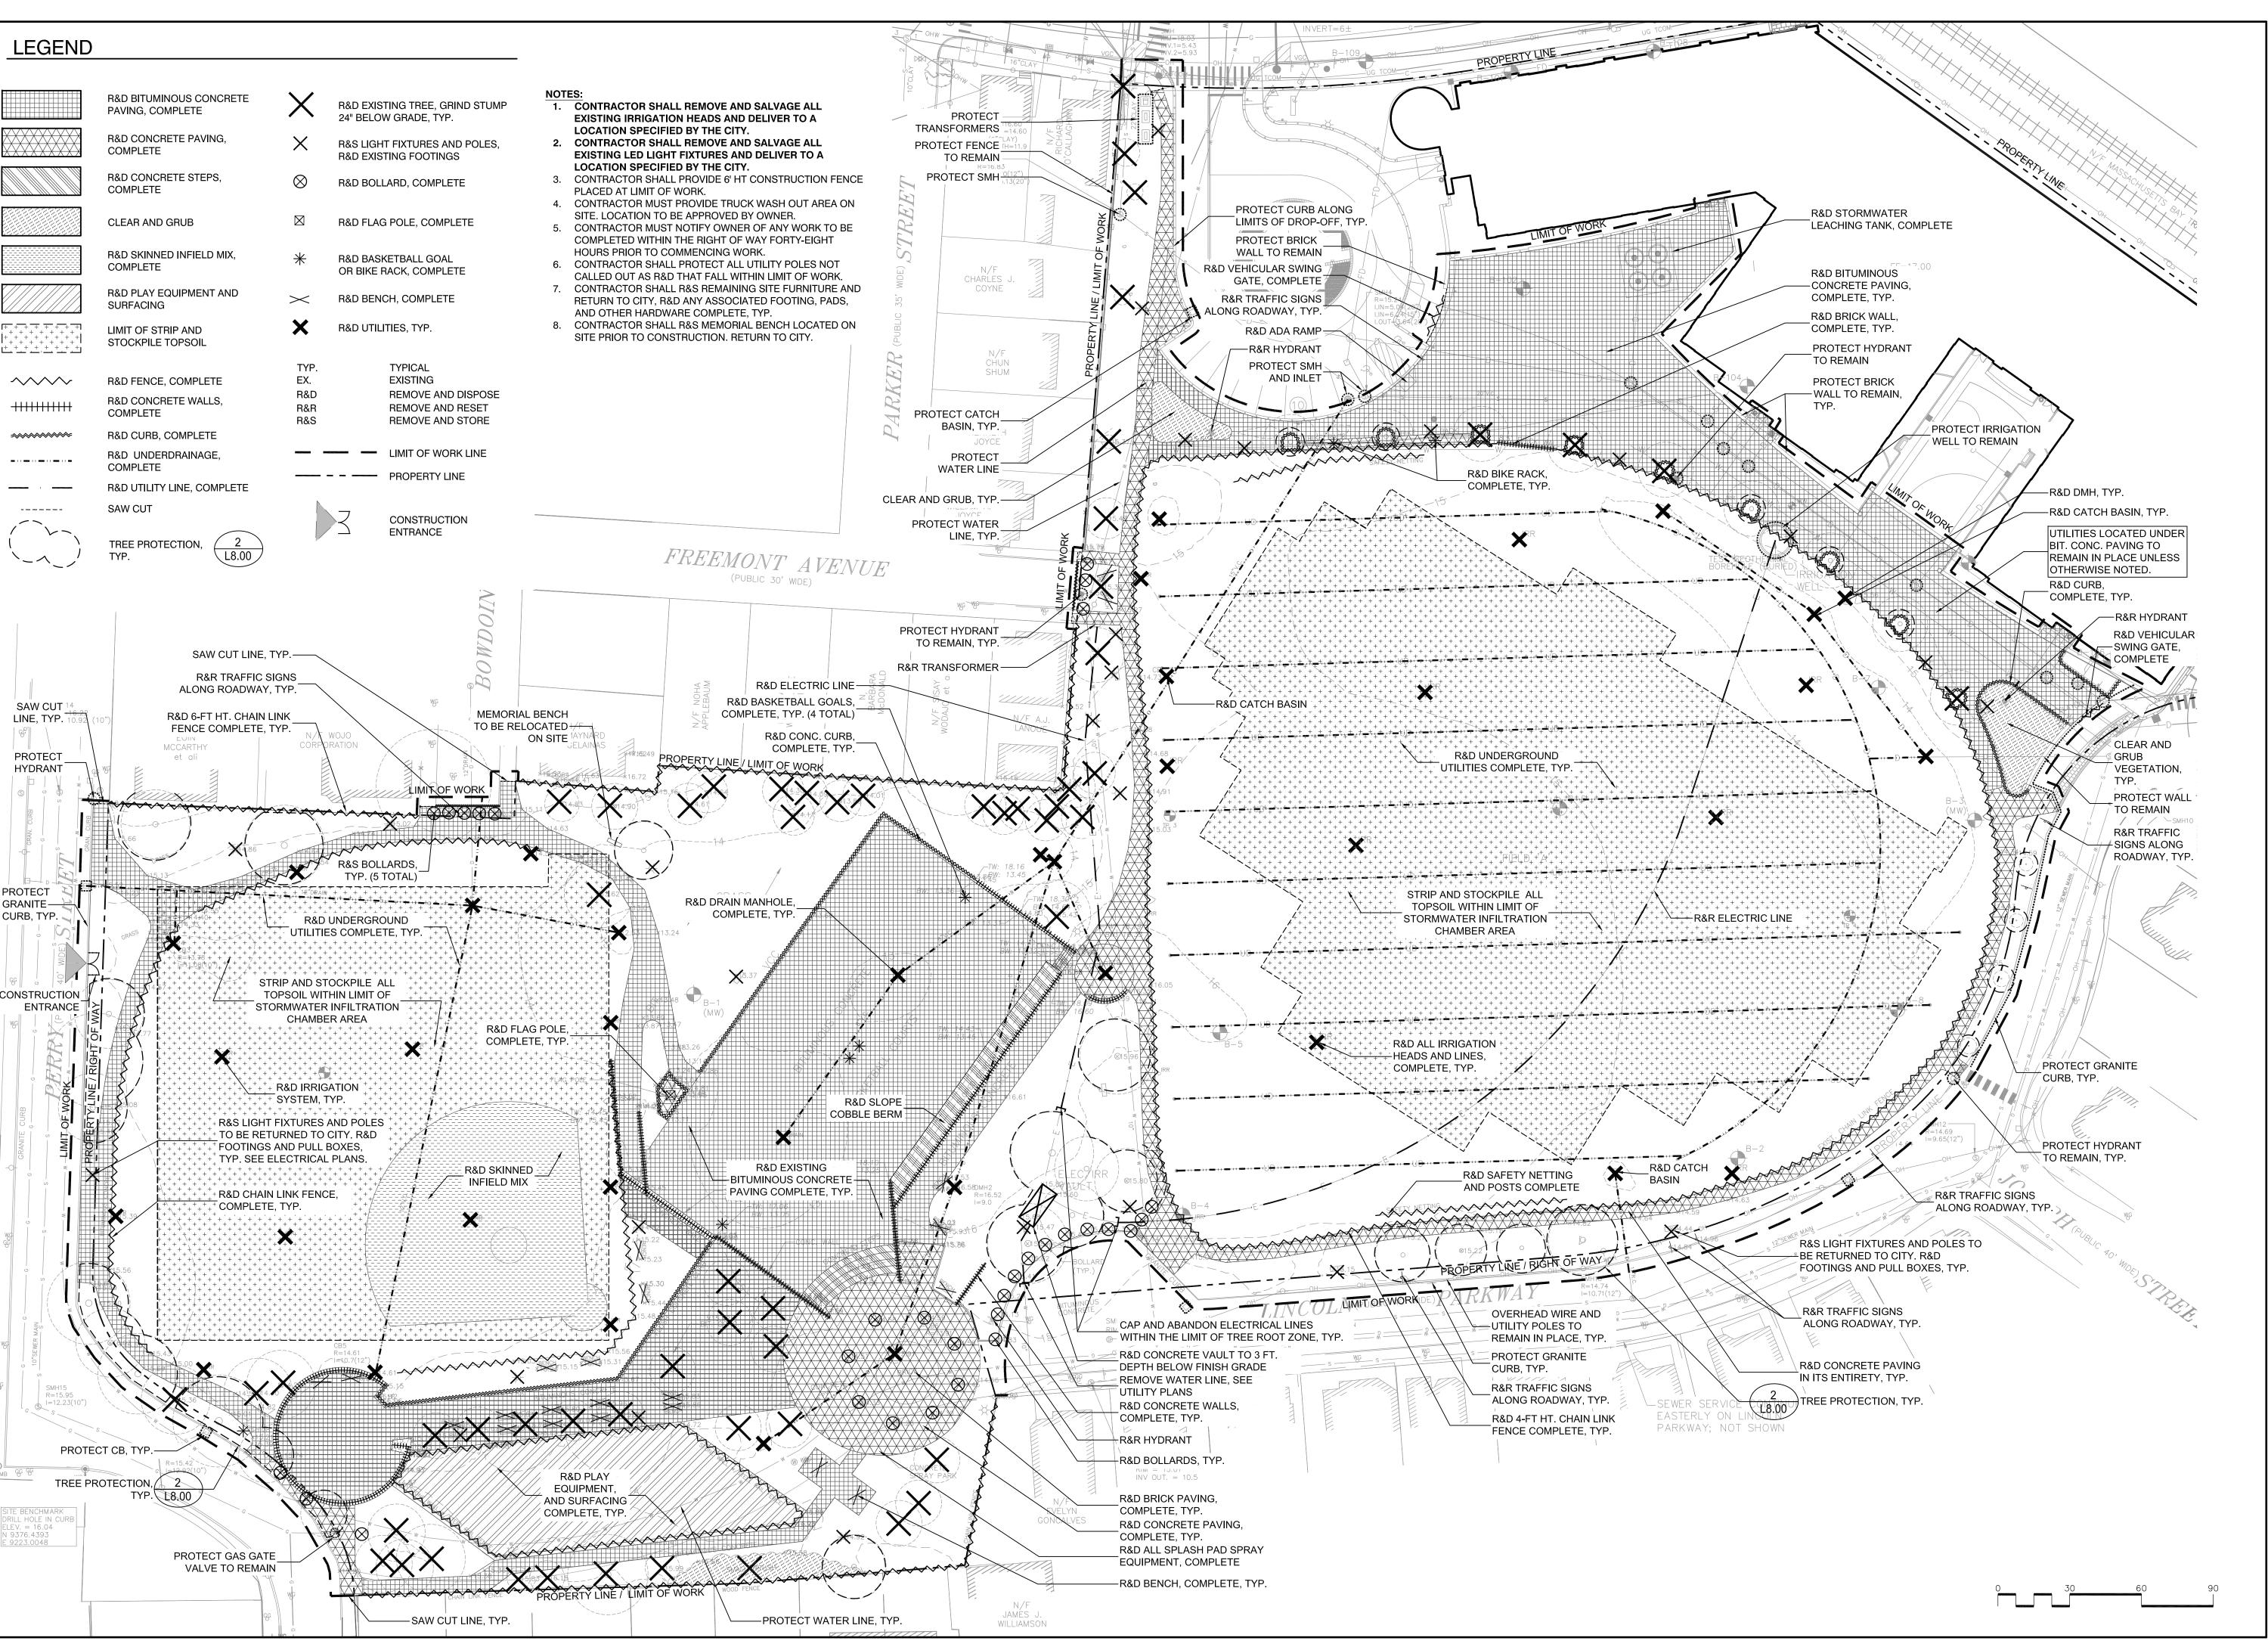

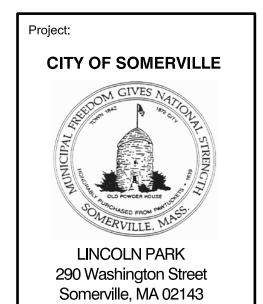




Consultants:





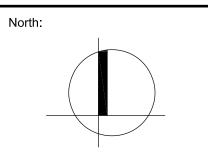

Re	visions:	
Rev	Date	Description
Â	03/07/16	ADDENDUM #1



CONSTRUCTION DOCUMENTS

Date: 02.24.2016

Scale: AS SHOWN

Drawn By: CCC/EJA/MBE

Reviewed By: BMK


Checked By:


Approved By: CFR

Drawing Title:

SITE PREPARATION AND DEMOLITION PLAN

heet Number:

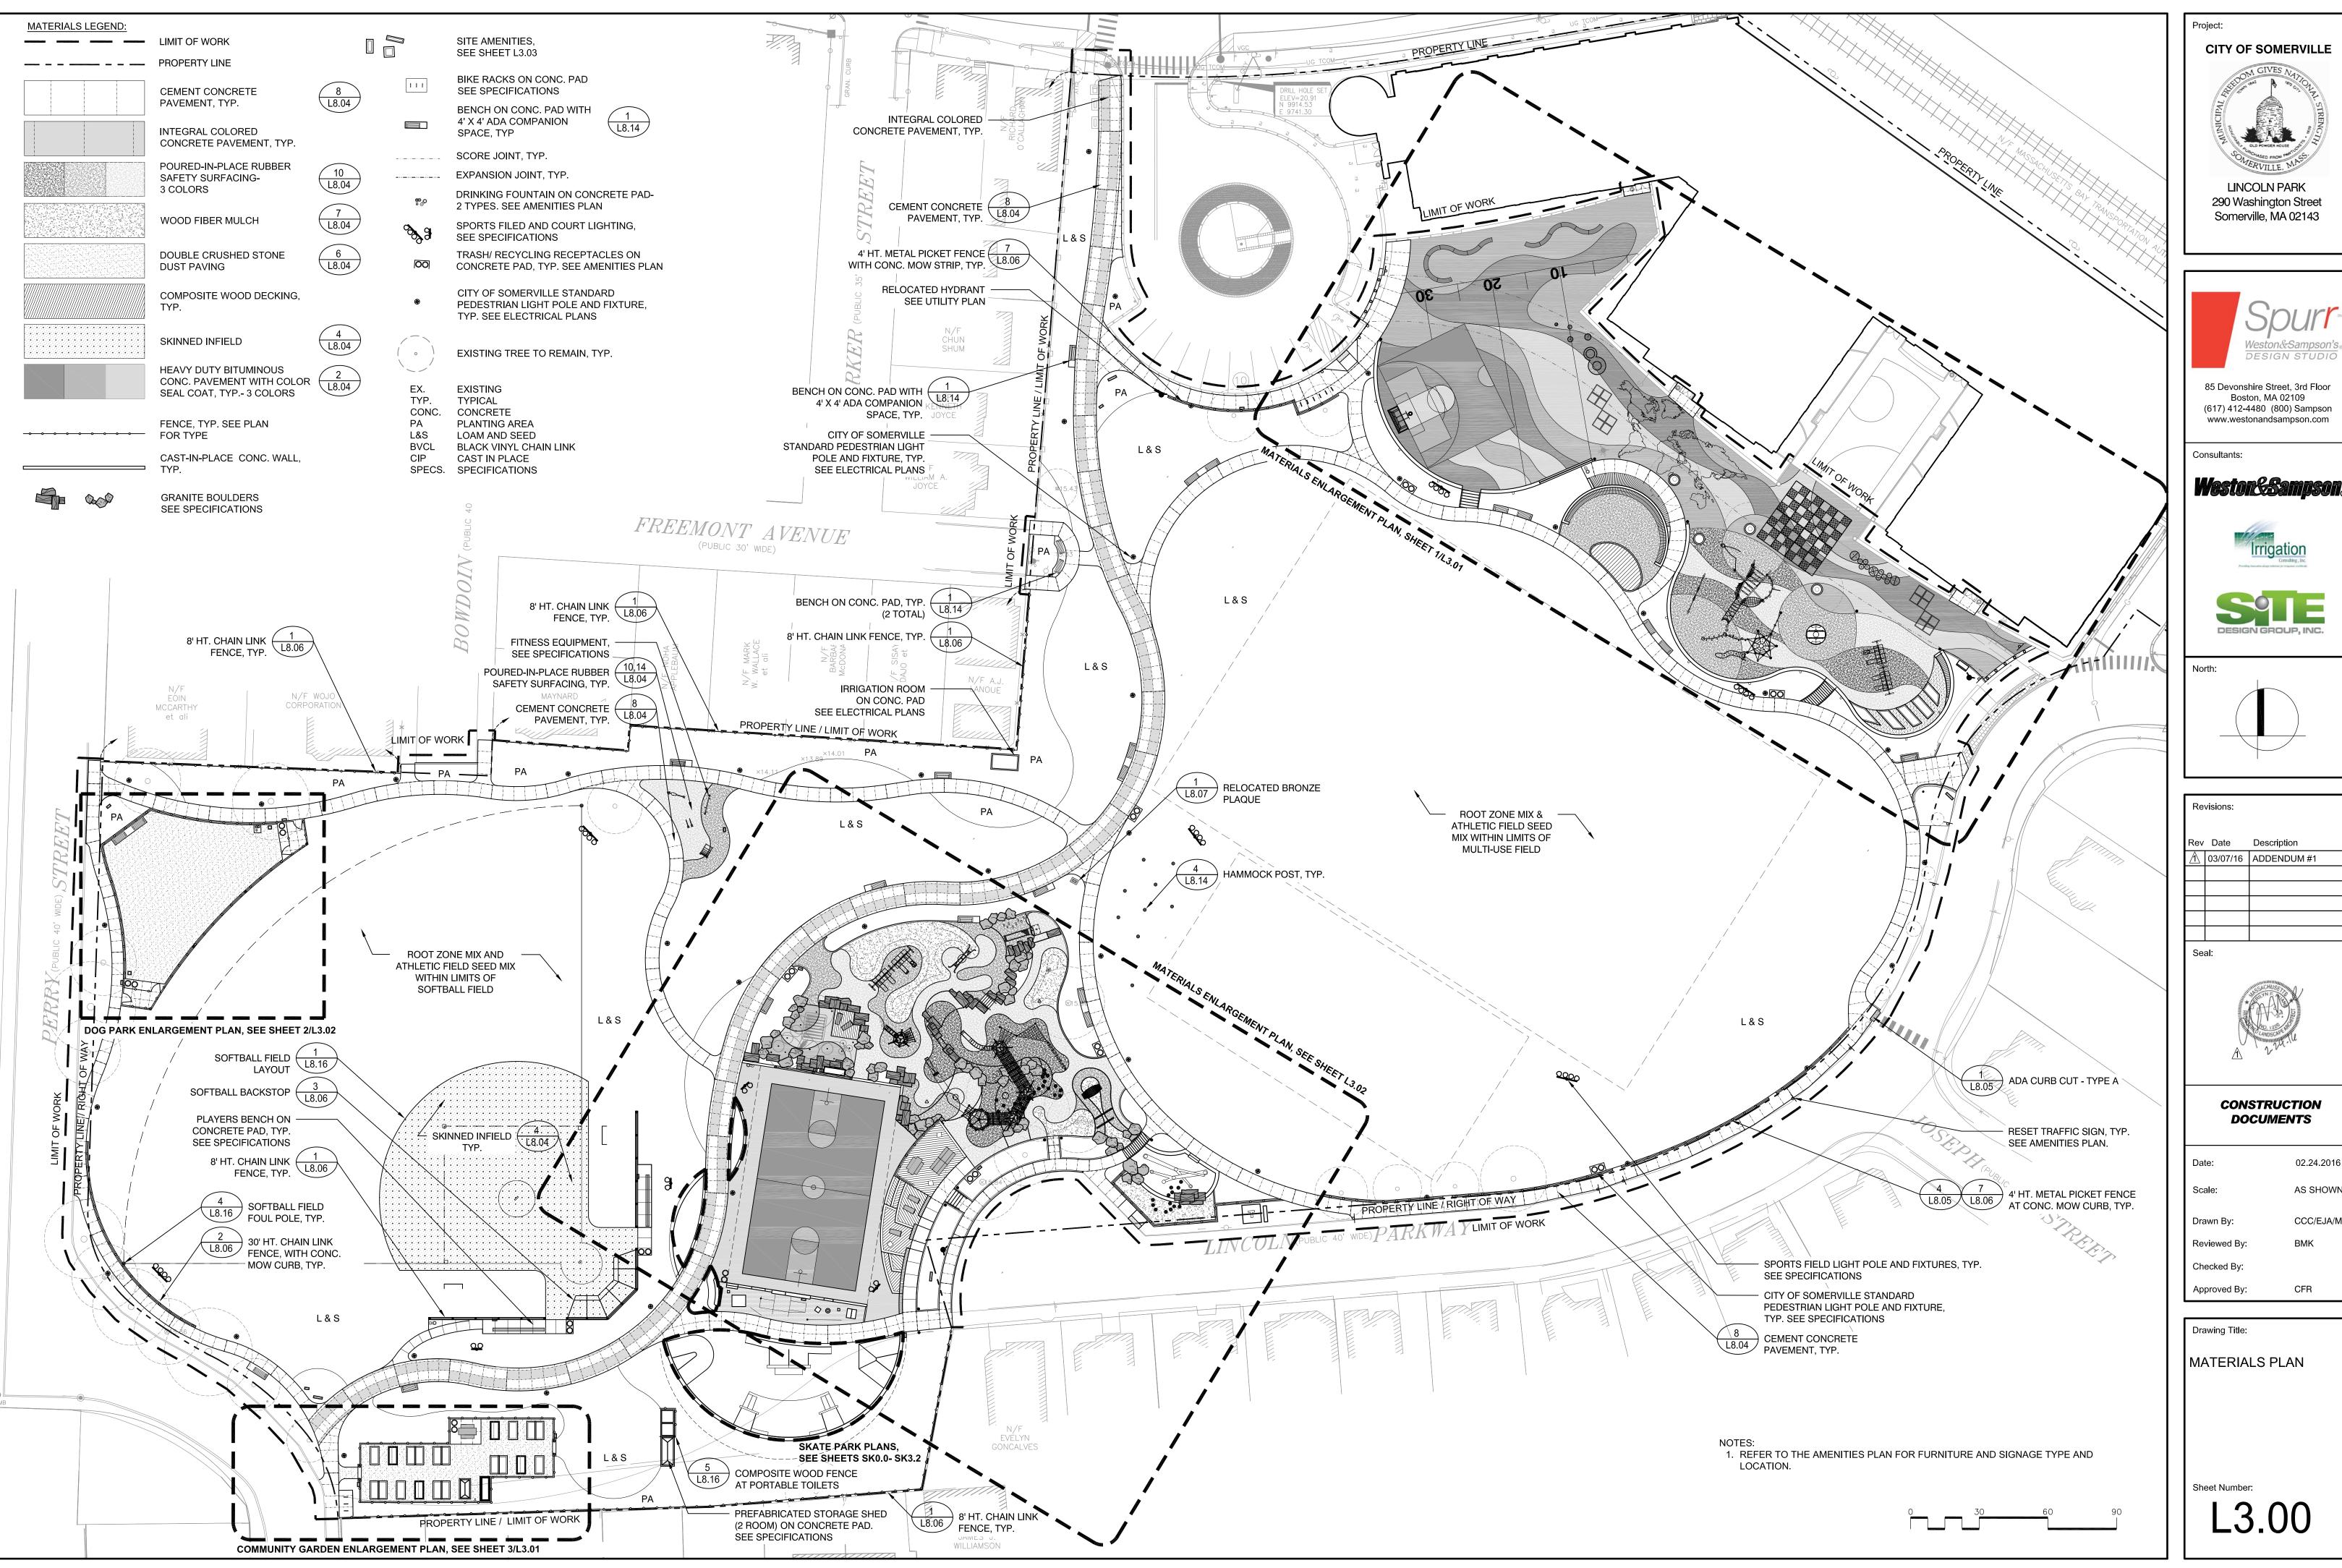


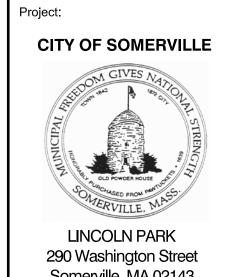







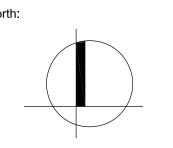



Revisions:		
Rev	Date	Description
Λ	03/07/16	ADDENDUM #1



CONSTRUCTION **DOCUMENTS**

02.24.2016 AS SHOWN CCC/EJA/MB

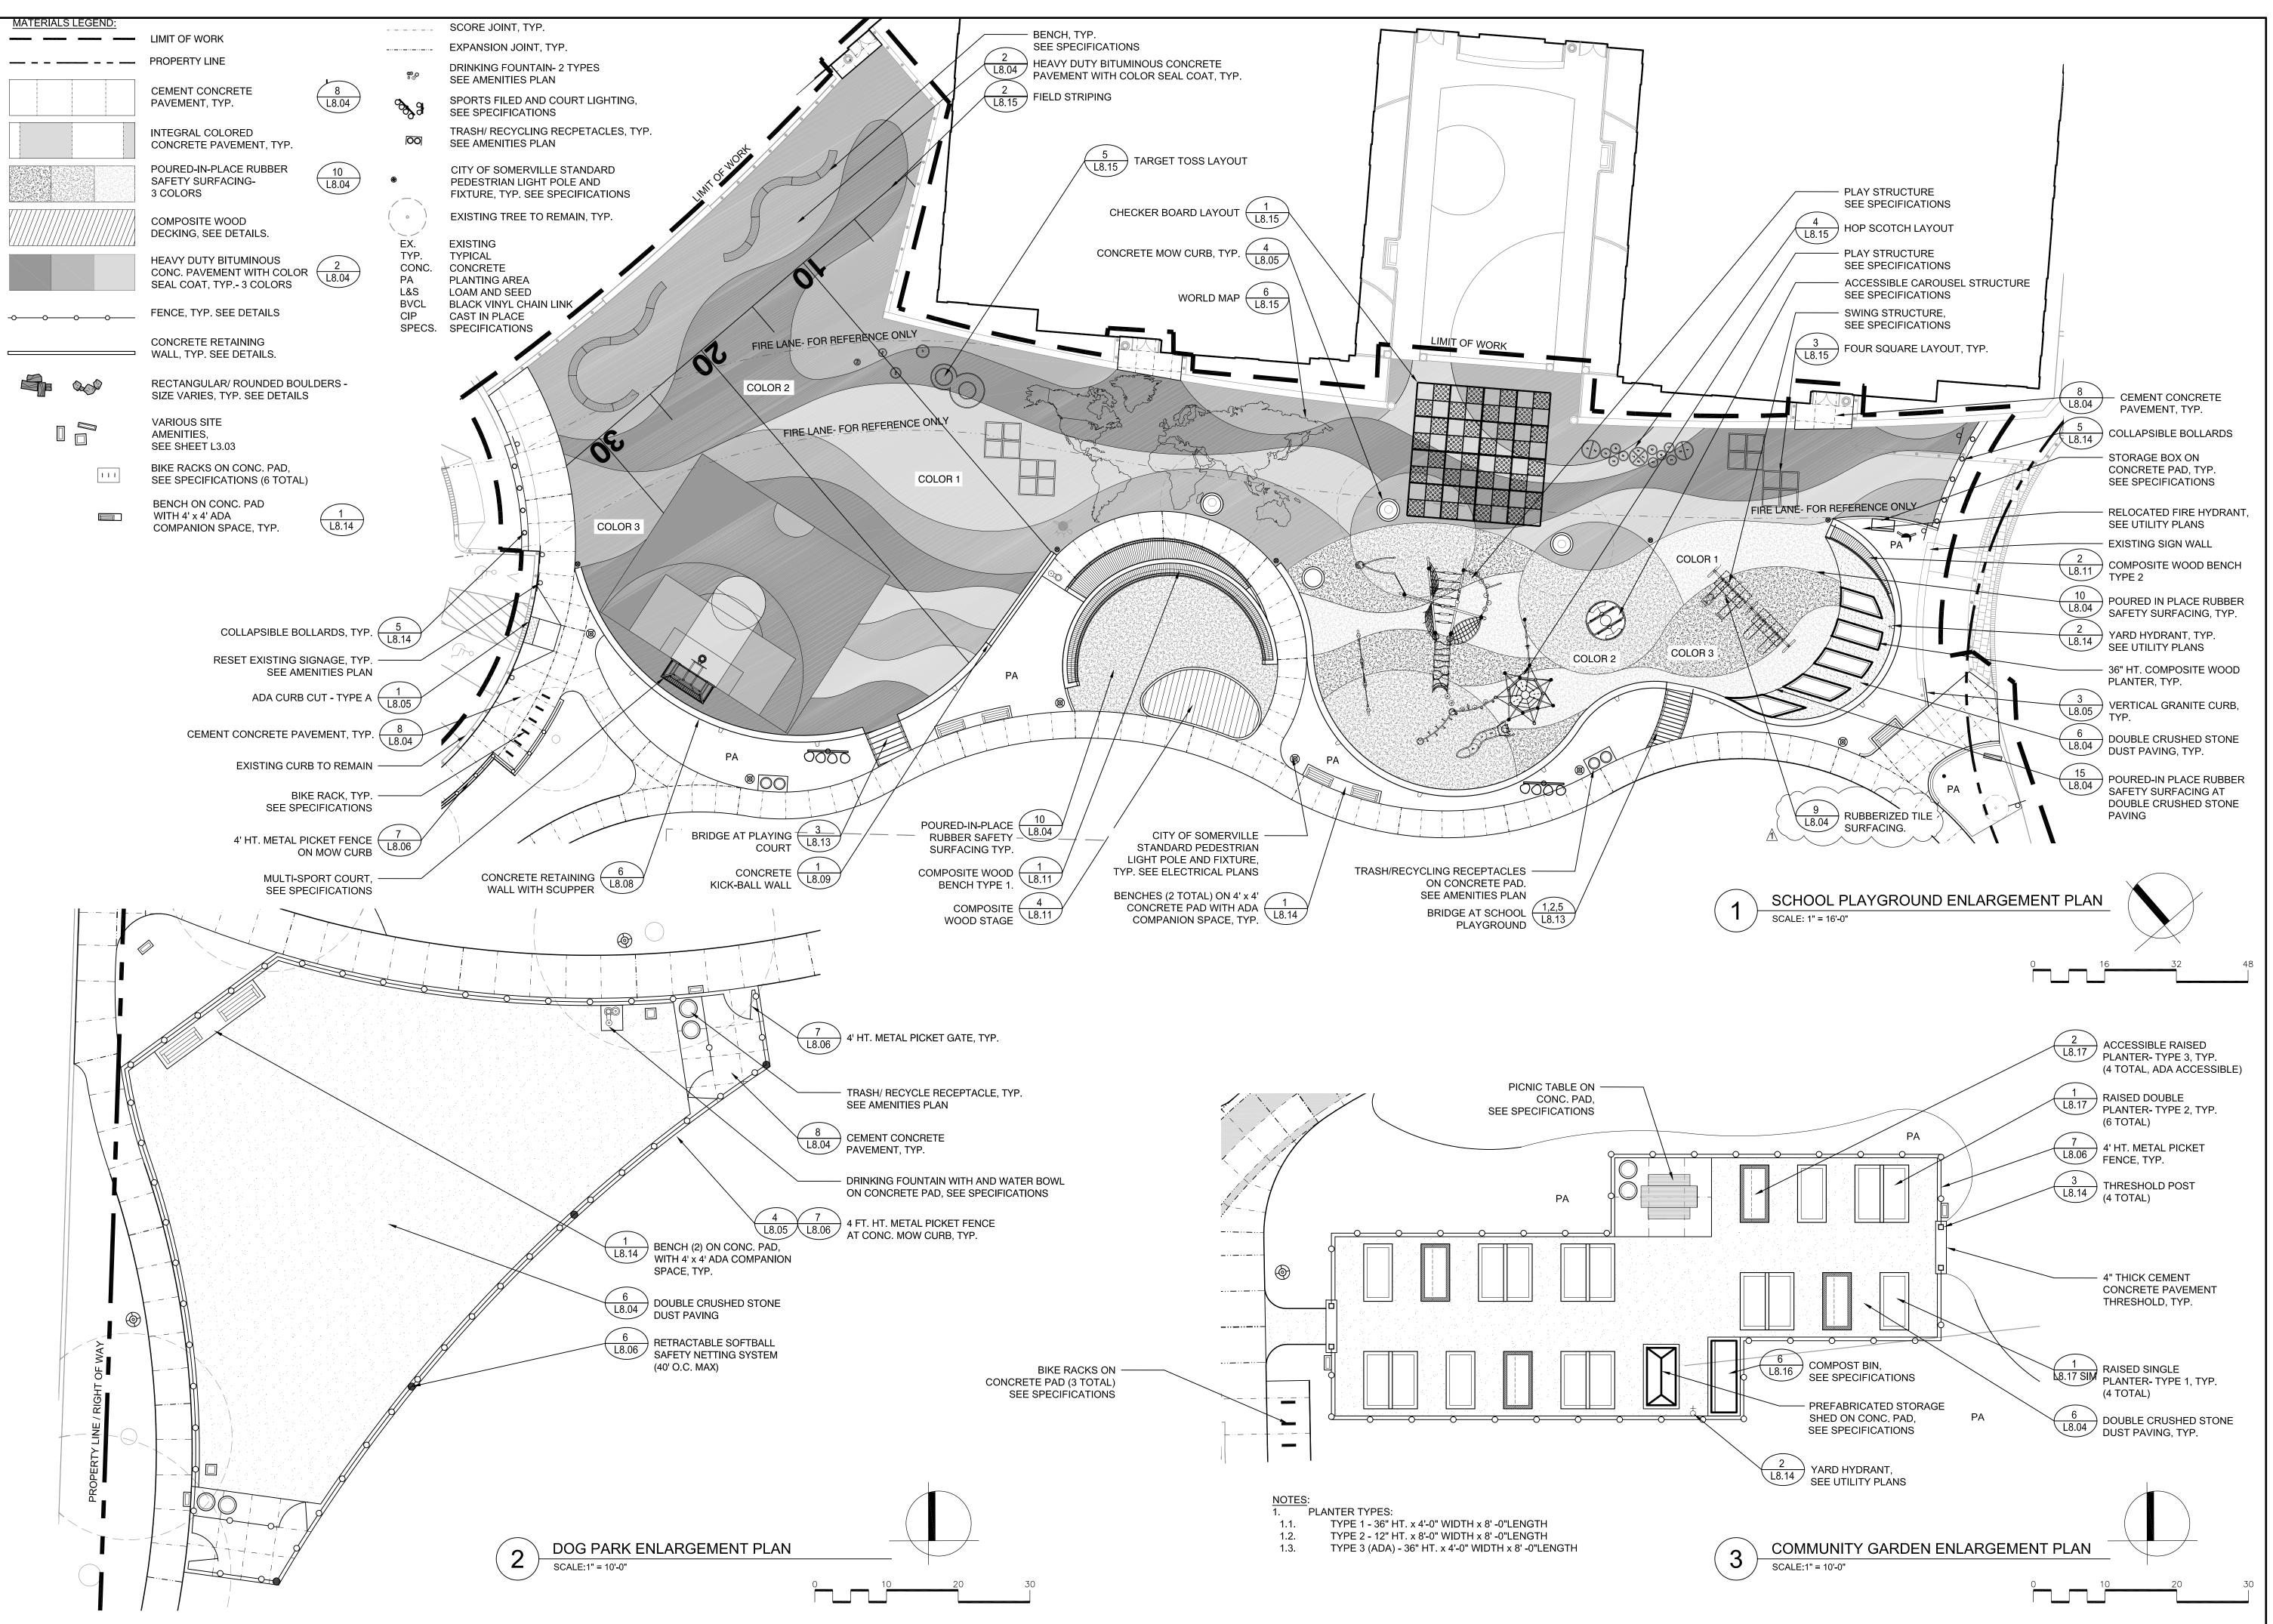

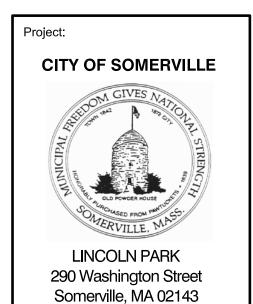



Consultants:

Weston&Sampson®





orth:

١.			
	Re	visions:	
	Rev	Date	Description
	A	03/07/16	ADDENDUM #1

____ Seal:



CONSTRUCTION DOCUMENTS

ate:	02.24.2016
cale:	AS SHOWN
rawn By:	CCC/EJA/MBE
eviewed By:	BMK

Checked By:


Approved By:


CFR

Drawing Title:

MATERIALS ENLARGEMENT PLANS

Sheet Number:

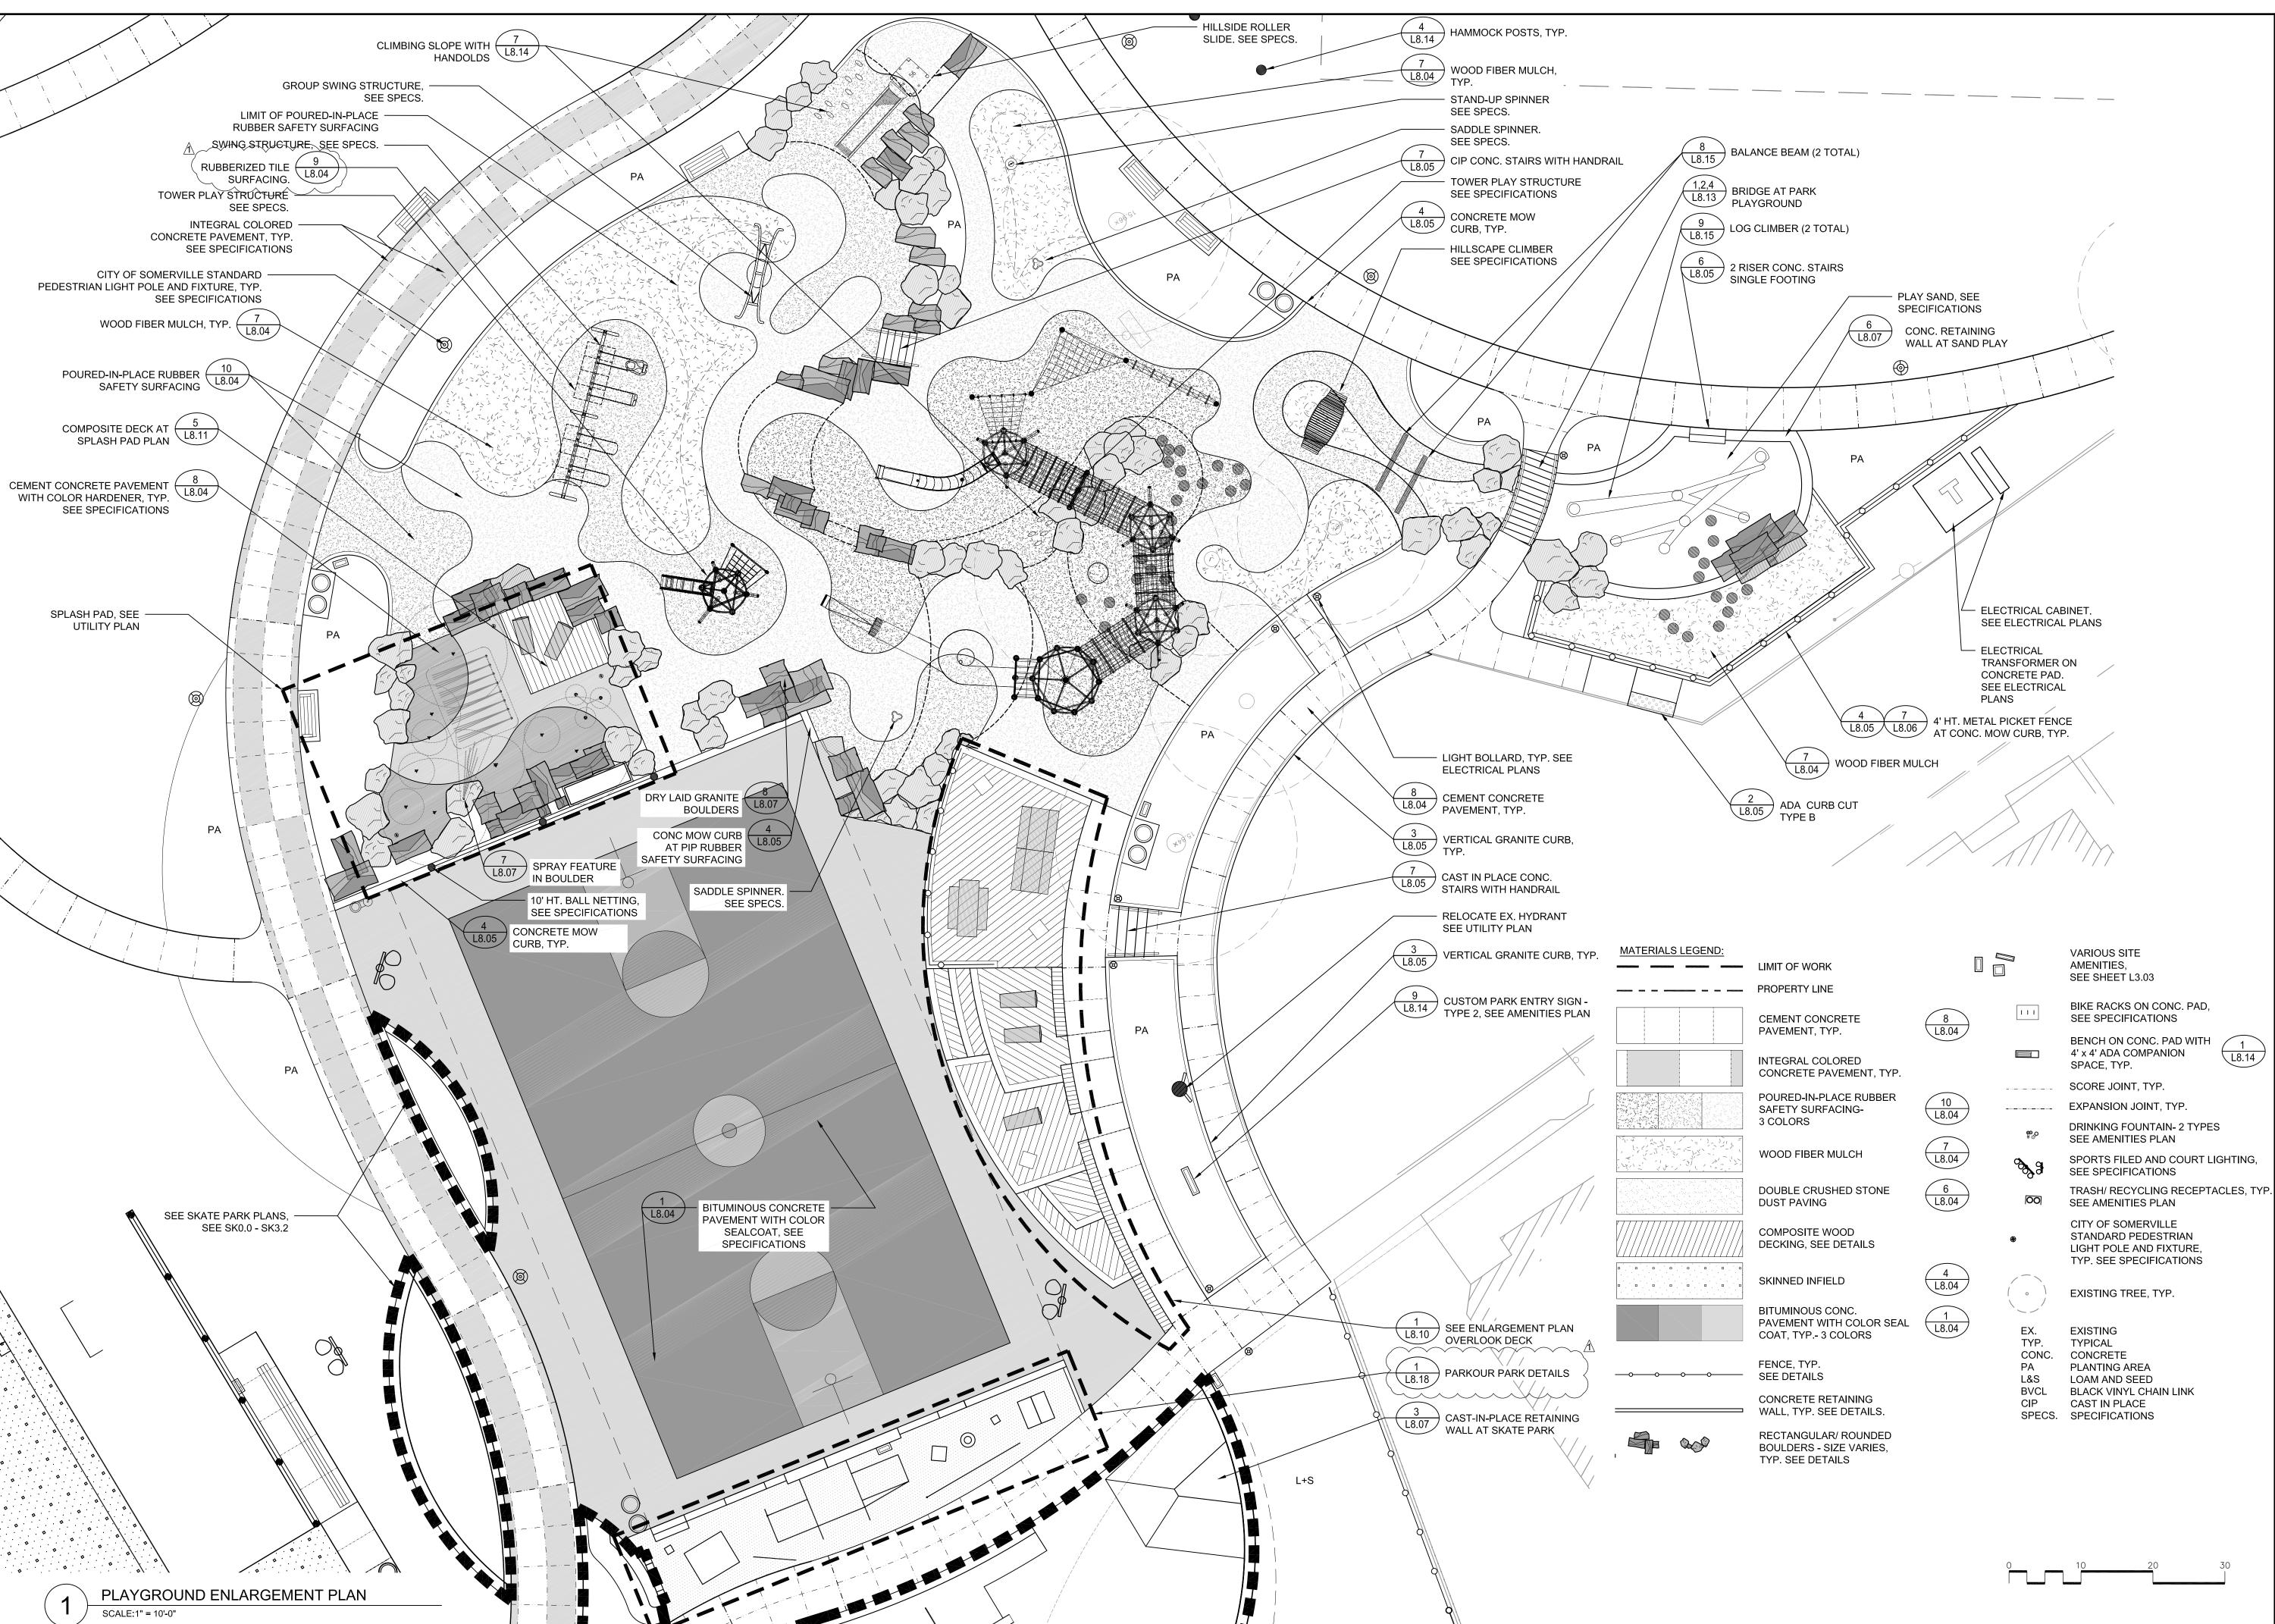

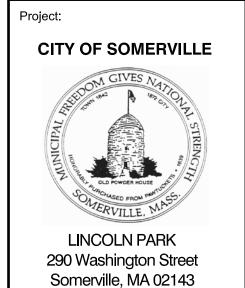




Consultants:

Weston&Sampson_®





North:

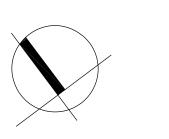

1			
	Re	visions:	
	D	Data	Description
	Rev	Date	Description
	\triangle	03/07/16	ADDENDUM #1
	Sea	al:	



CONSTRUCTION DOCUMENTS

e:	02.24.2016
ıle:	AS SHOWN
wn By:	CCC/EJA/MBE
viewed By:	вмк

Checked By:

Approved By: CFR

Drawing Title:


MATERIALS ENLARGEMENT PLANS

Sheet Number:

L3.02





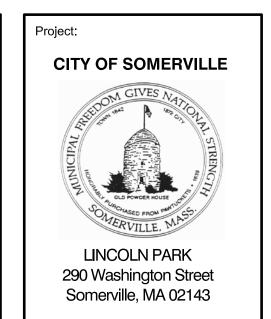




Consultants:





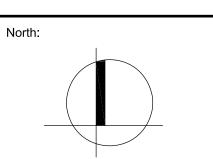

Re	Revisions:	
Rev	Date	Description
\triangle	03/07/16	ADDENDUM #1
S0.	a lu	



CONSTRUCTION DOCUMENTS

Date:	02.24.2016
Scale:	AS SHOWN
Drawn By:	CCC/EJA/ME
Reviewed By:	вмк


Checked By:
Approved By:


Drawing Title:

LAYOUT PLAN

eet Number:

L4.00

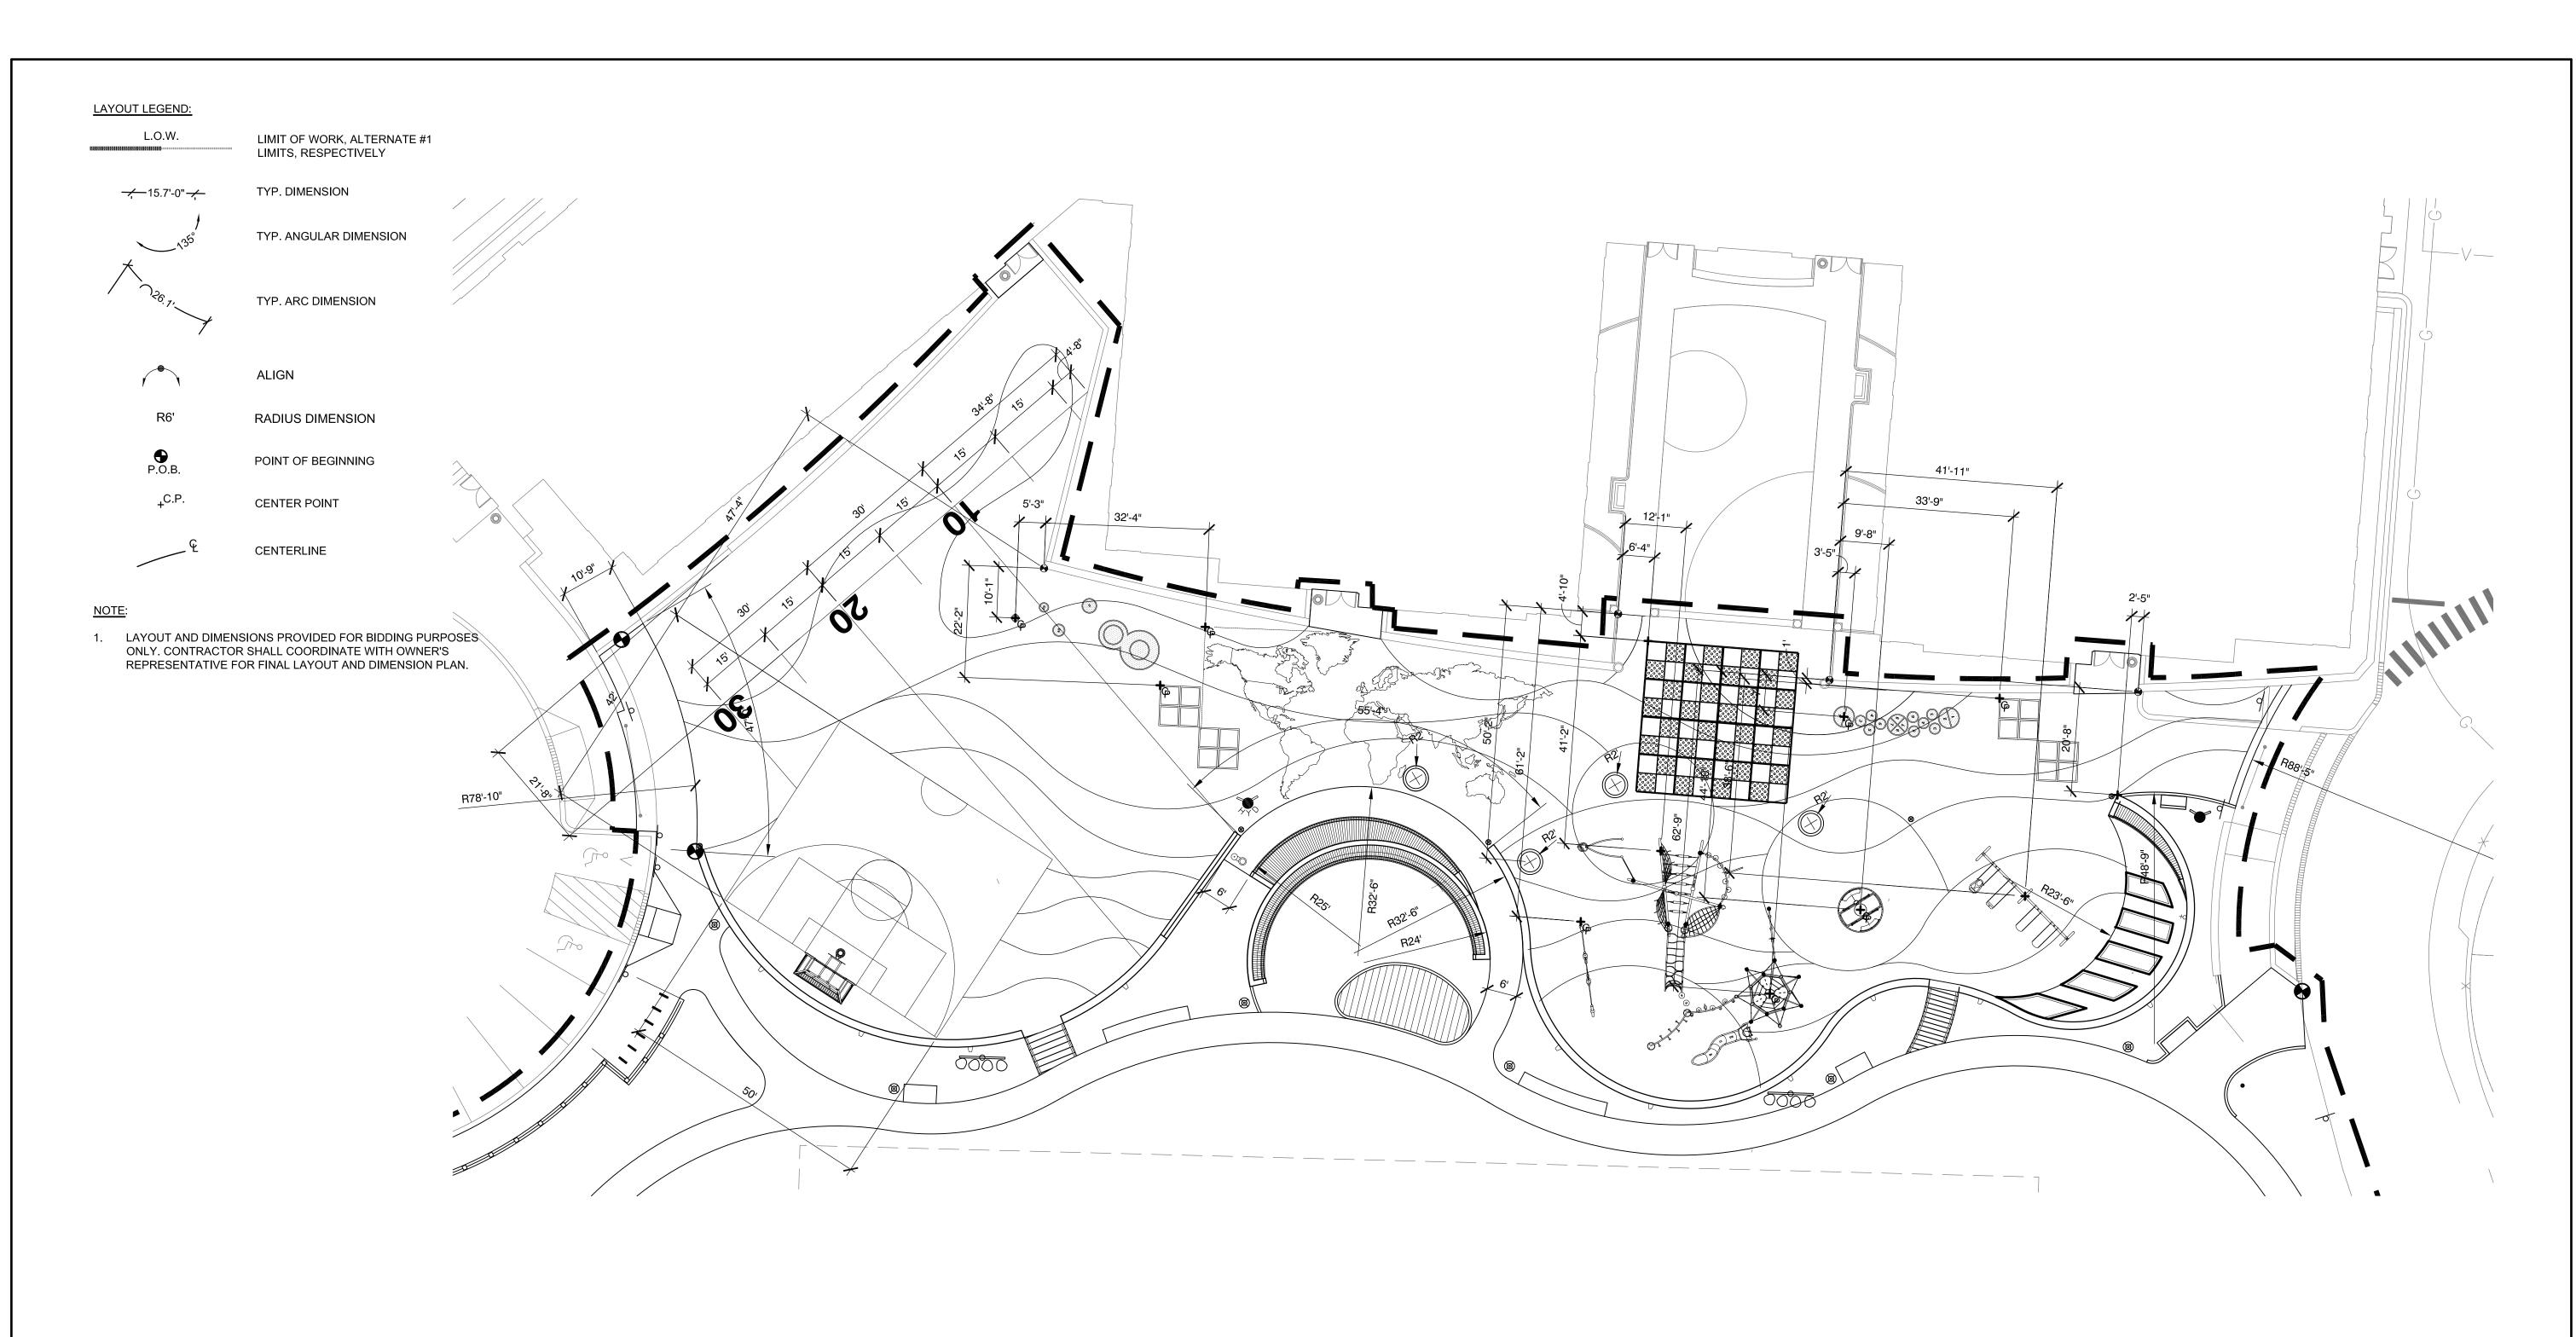

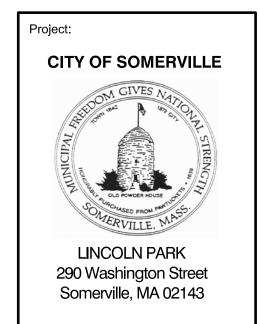




Consultants:







 

Revisions:	

Re	Revisions:			
Rev	Date	Description		
\triangle	03/07/16	ADDENDUM #1		



CONSTRUCTION DOCUMENTS

Date:	02.24.2016
Scale:	AS SHOWN
Drawn By:	CCC/EJA/ME
Reviewed By:	вмк
Checked By:	


Drawing Title:

LAYOUT PLAN ENLARGEMENT

Sheet Number

L4.01



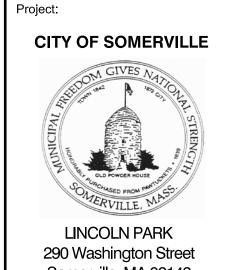




85 Devonshire Street, 3rd Floor Boston, MA 02109 (617) 412-4480 (800) Sampson

Weston&Sampson®





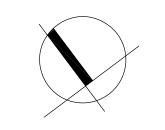



	Re	visions:	
	Rev	Date	Description
	\triangle	03/07/16	ADDENDUM #1
/			
/)			
	Sea	al:	



CONSTRUCTION **DOCUMENTS**

02.24.2016 AS SHOWN CCC/EJA/MBE

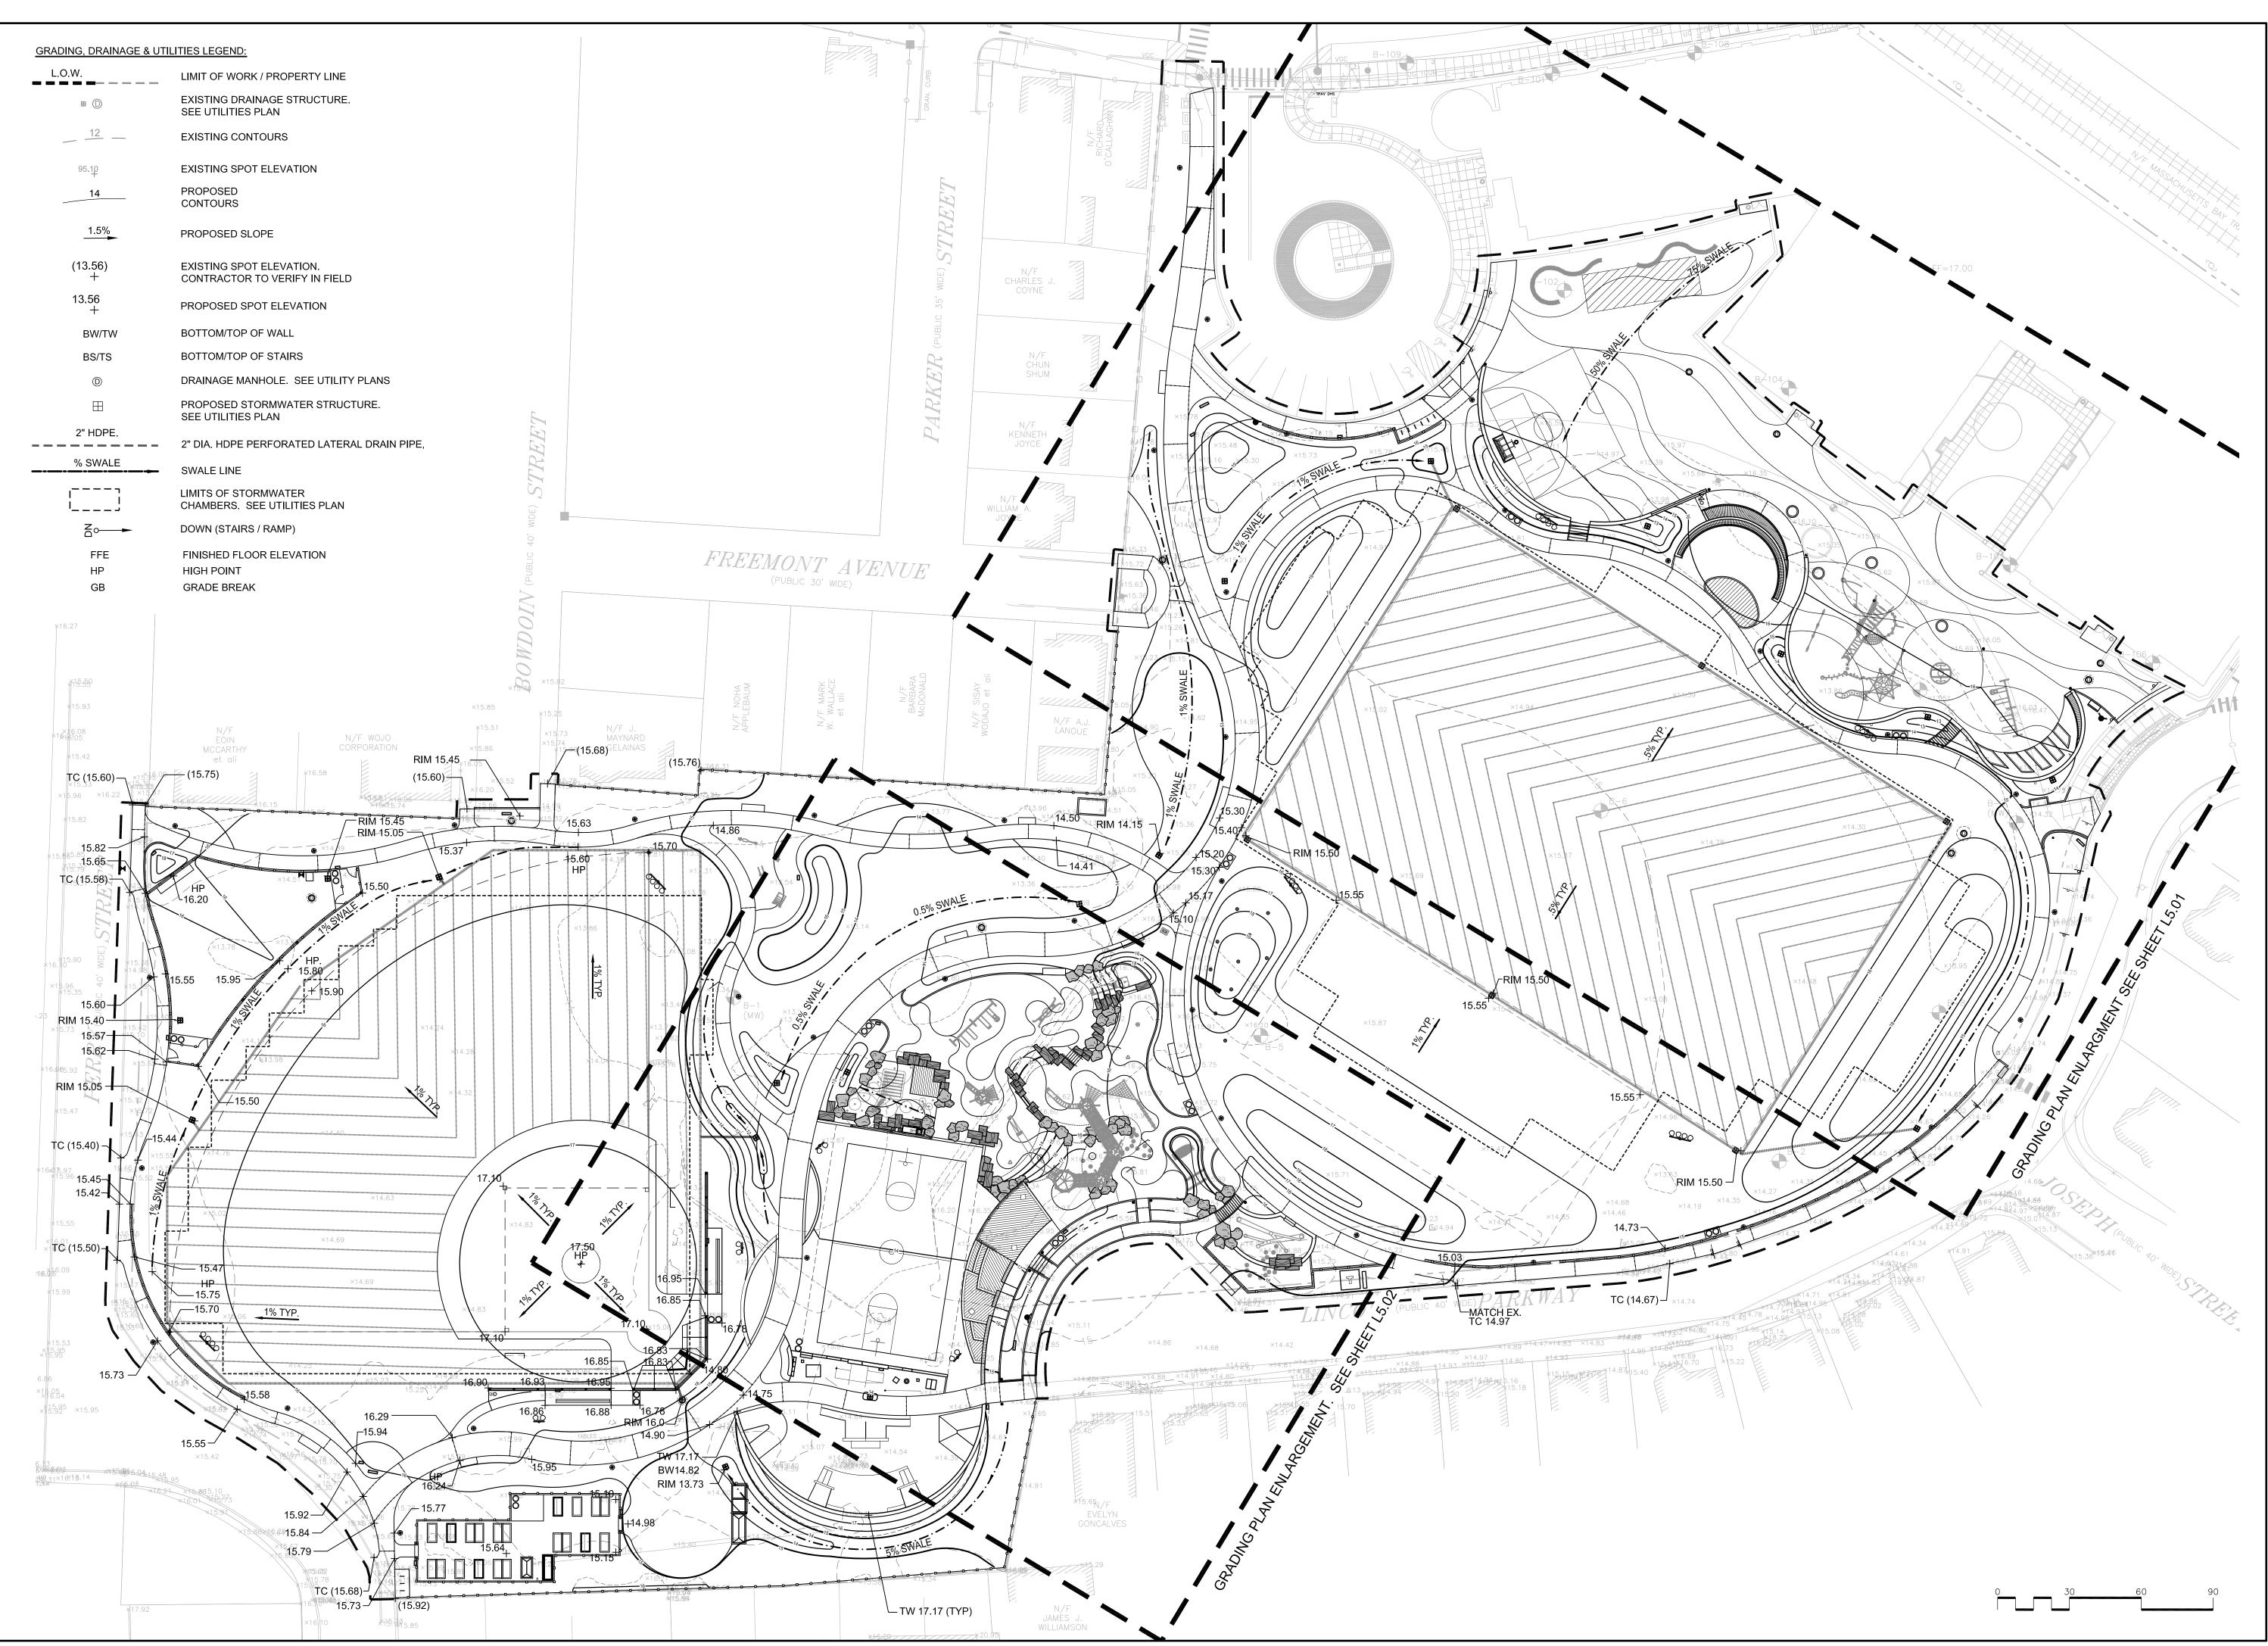

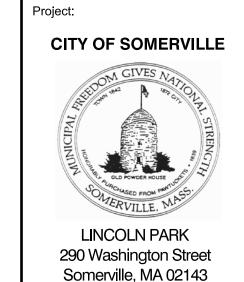




Consultants: Weston&Sampson





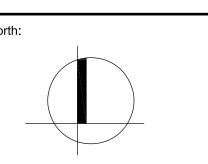


Re	visions:	
Rev	Date	Description
Λ	03/07/16	ADDENDUM #1



CONSTRUCTION **DOCUMENTS**

Date:	02.24.2016
Scale:	AS SHOWN
Drawn By:	CCC/EJA/ME

GRADING PLAN

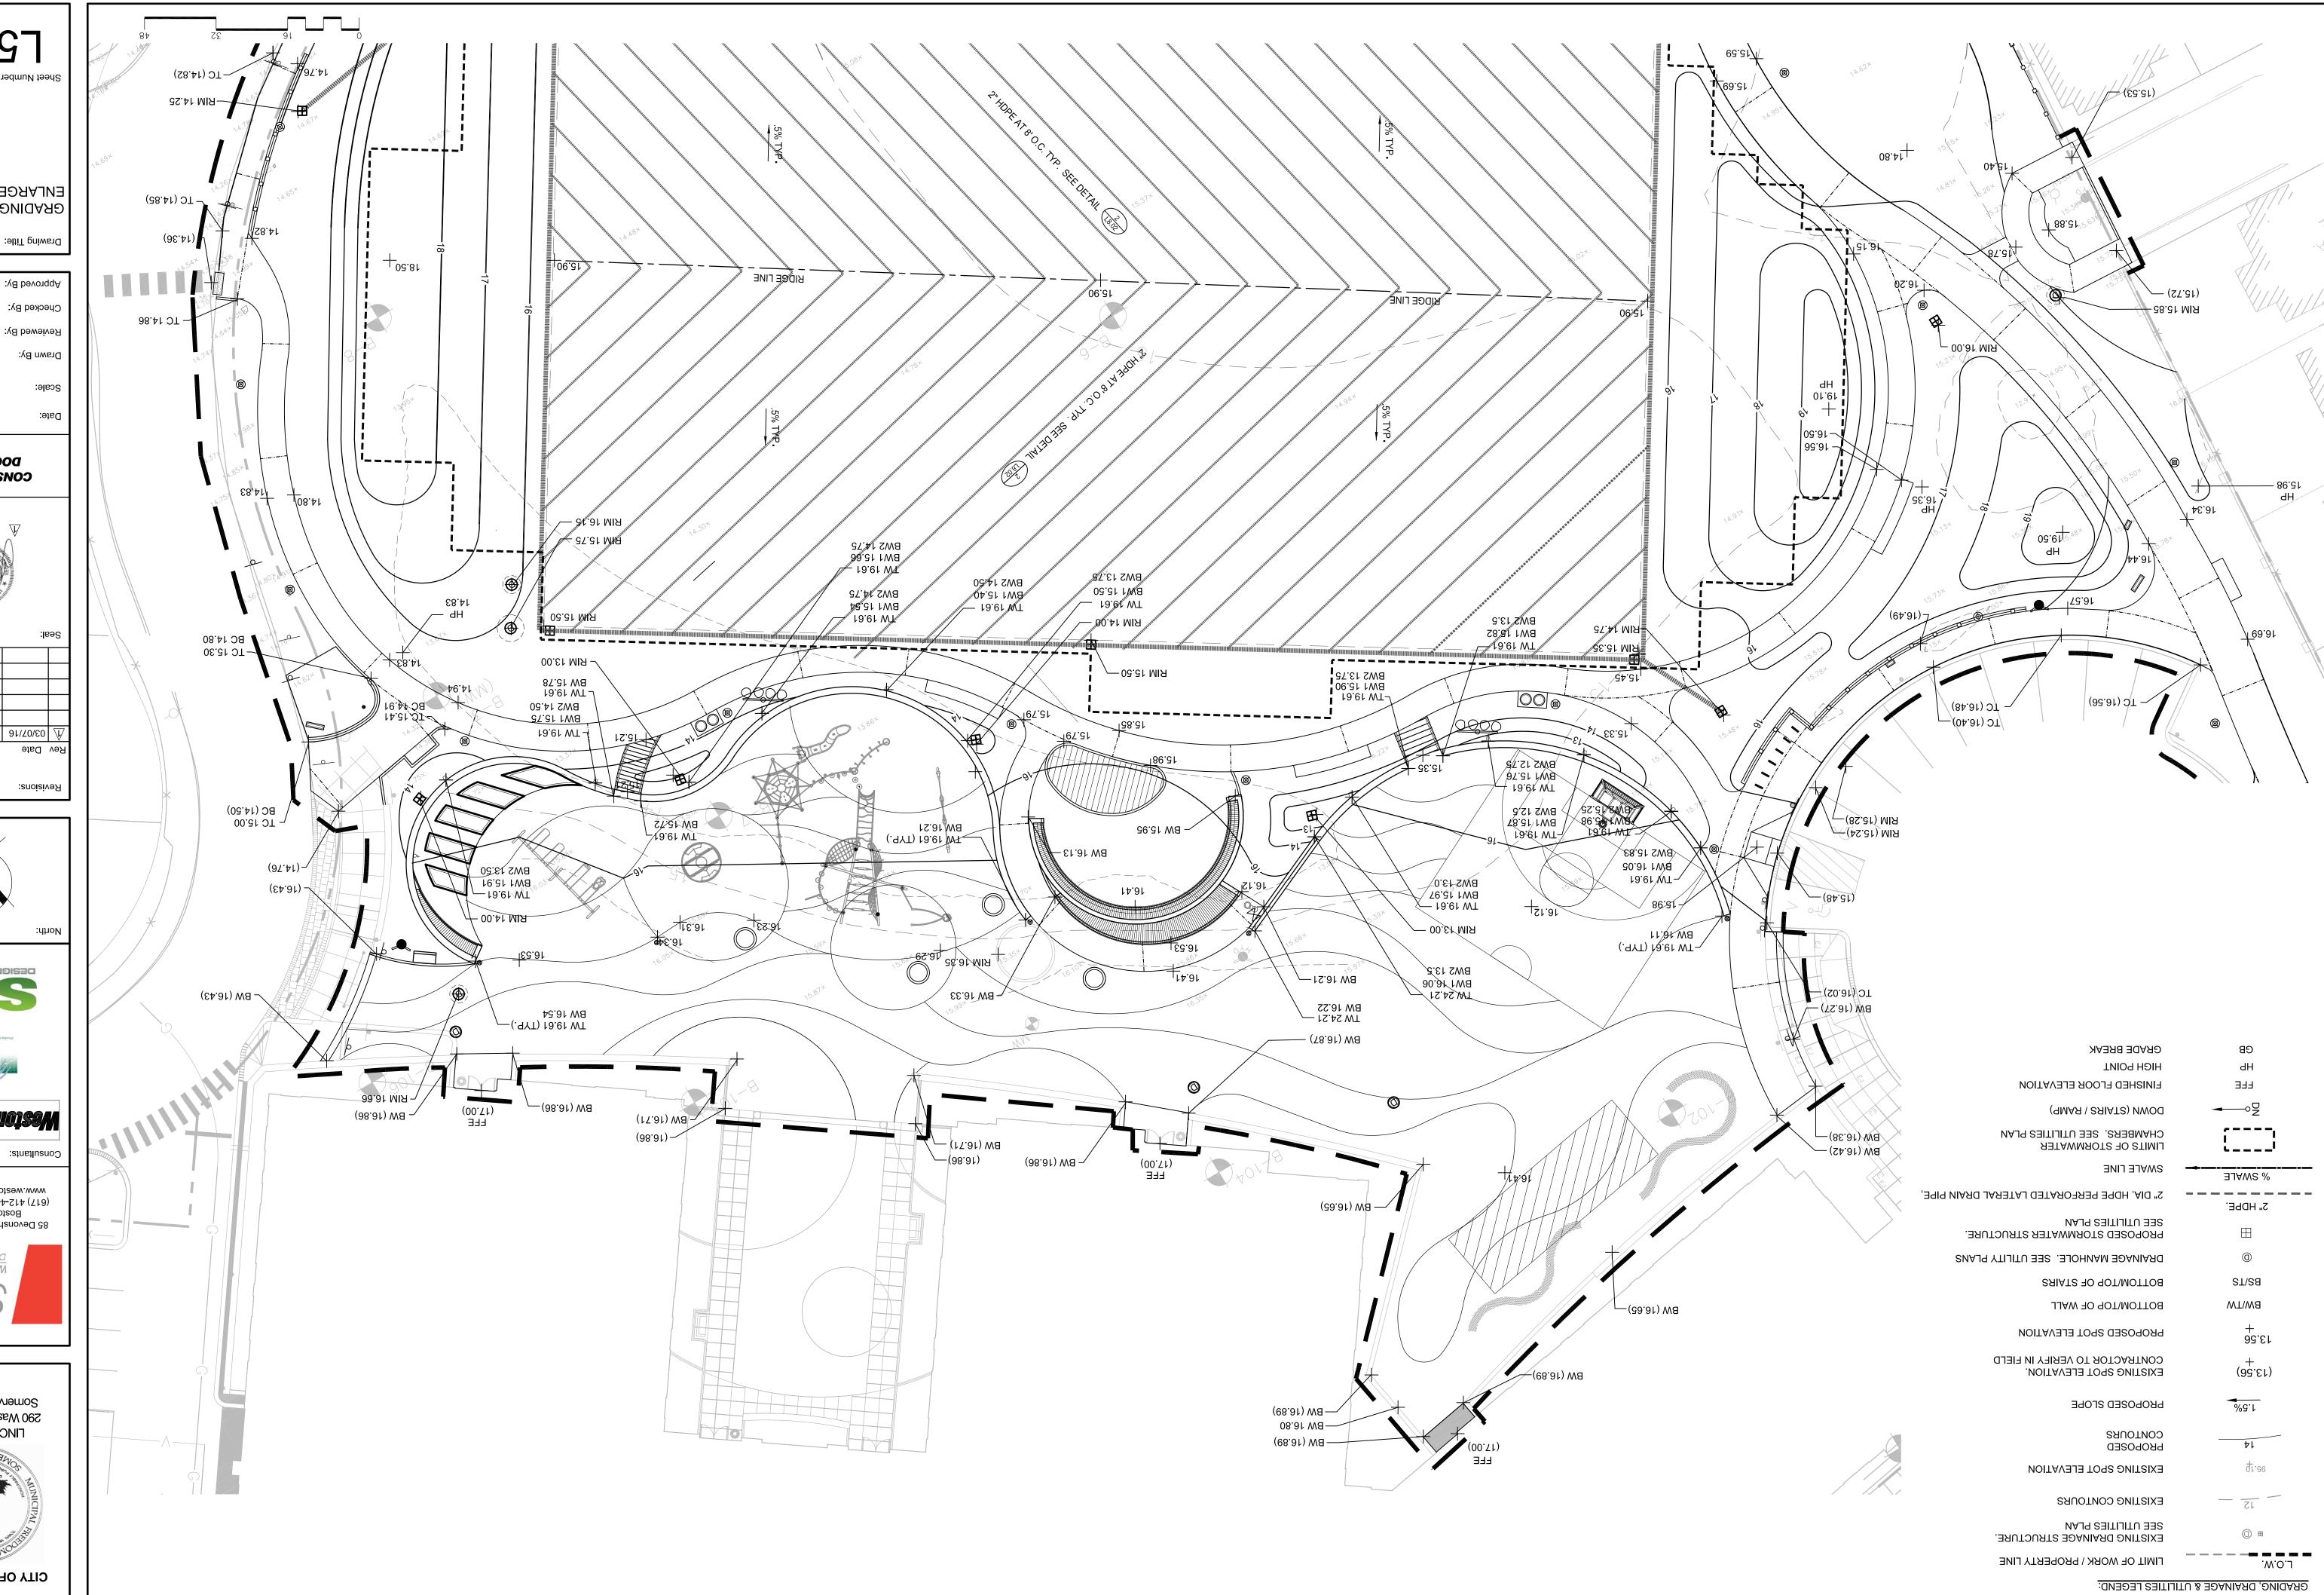

ENLARGEMENT ORADING PLAN


Approved By:	CFR
Checked By:	
Reviewed By:	ВМК
Drawn Ву:	CCC/E1A/MBE
Scale:	NWOH2 SA

02.24.2016

DOCUMENTS CONSTRUCTION



	: 0	9
		L
		L
ADDENDUM #1	91/20/60	7
Description	Date	۸
	:ouolou	

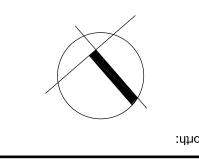




www.westonandsampson.com nosqms2 (008) 0844-214 (718) 90120 AM ,notsoB 85 Devonshire Street, 3rd Floor







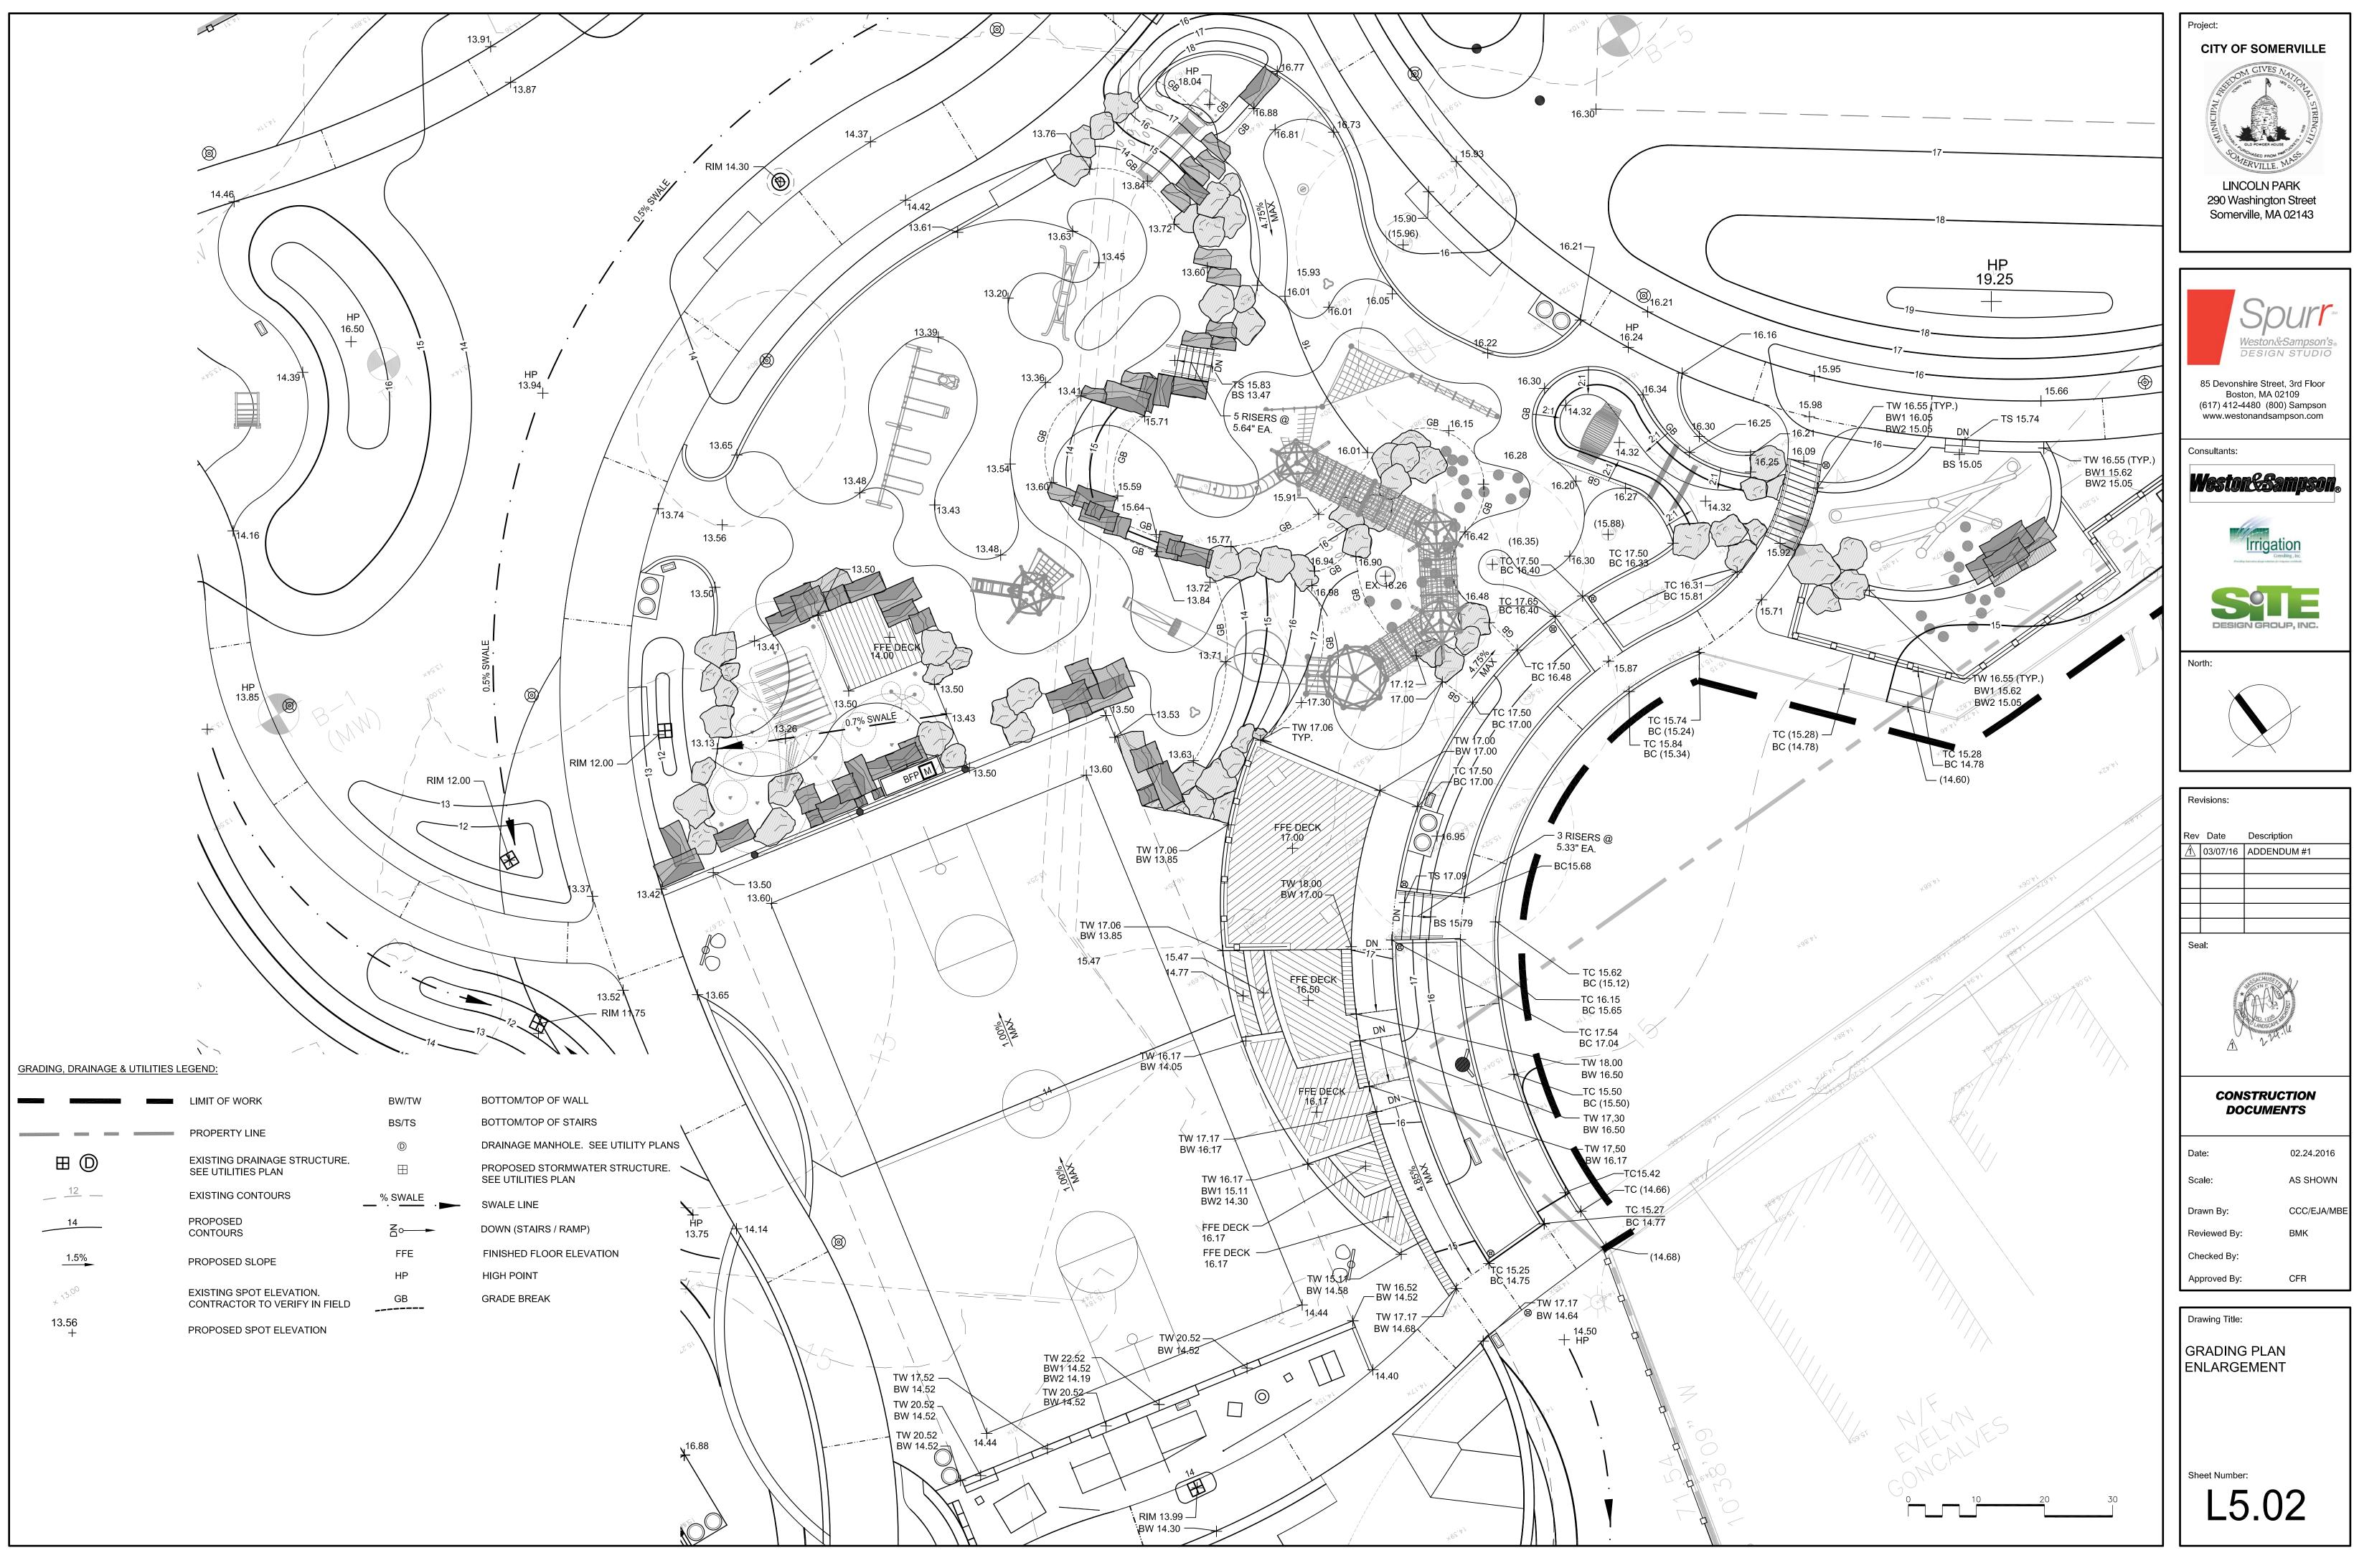





Re	visions:		
Rev	Date	Description	
Â	03/07/16	ADDENDUM #1	

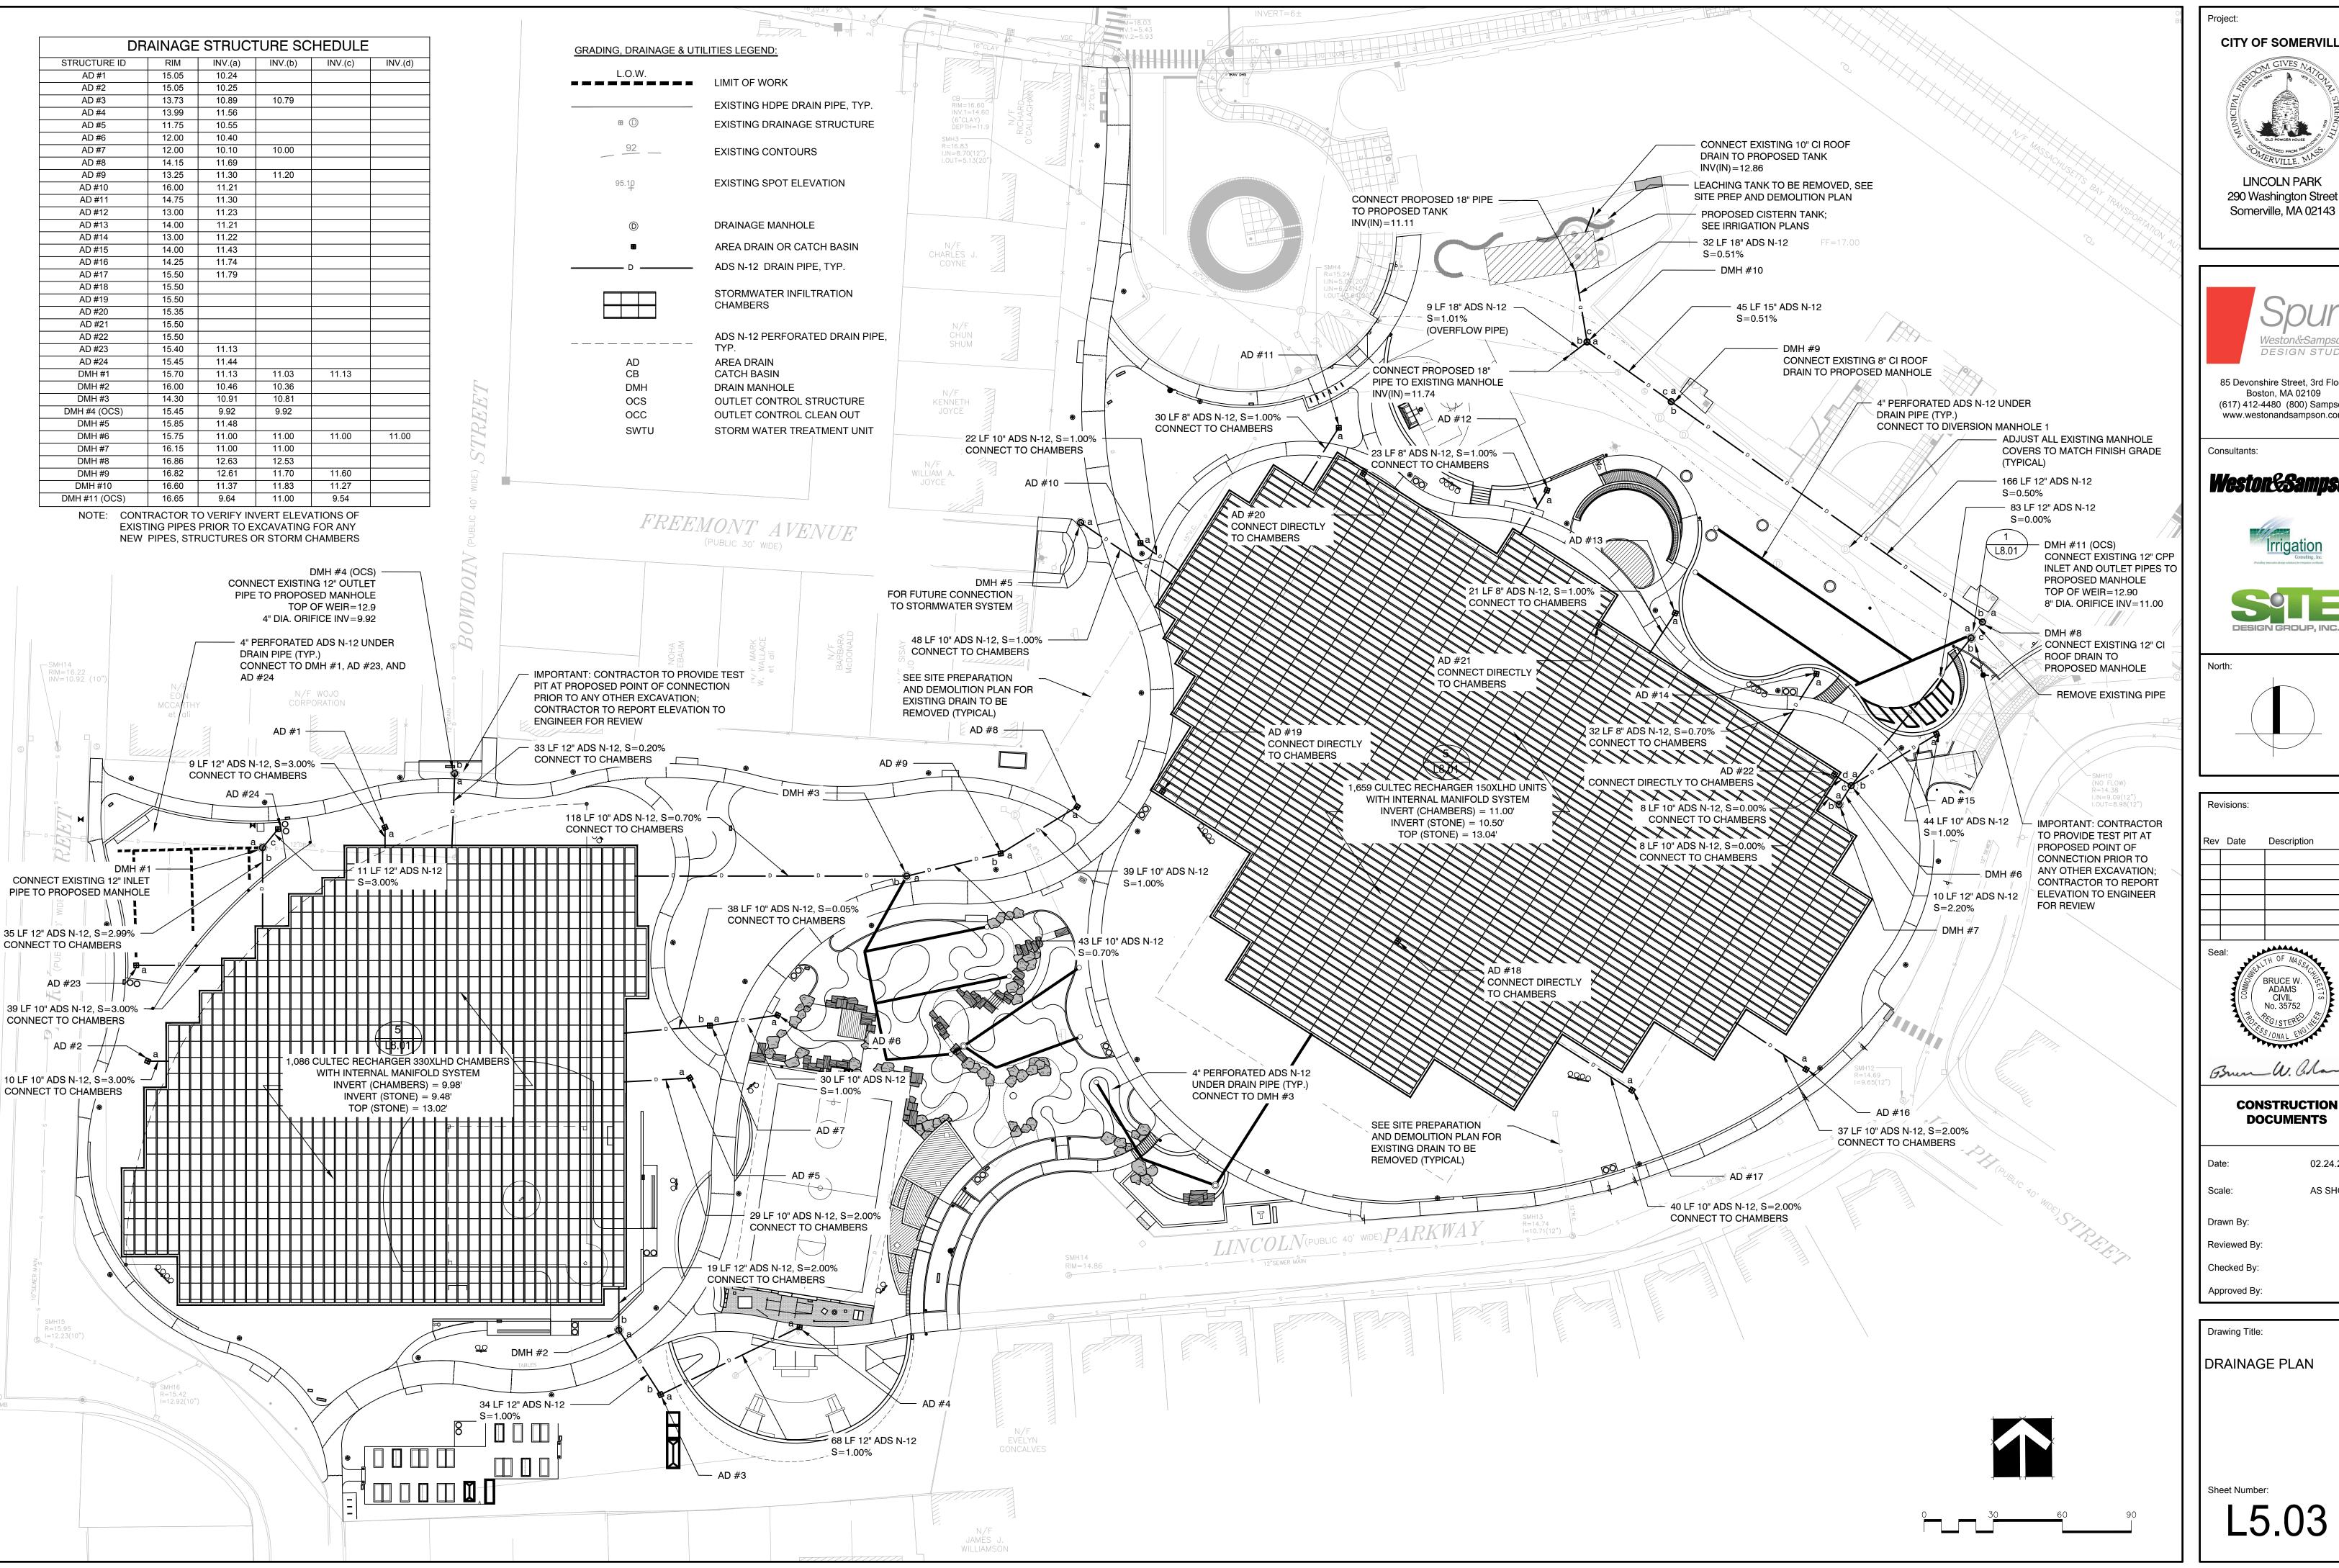


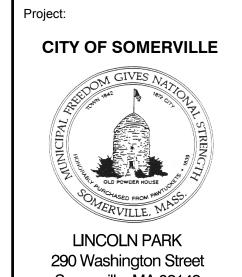

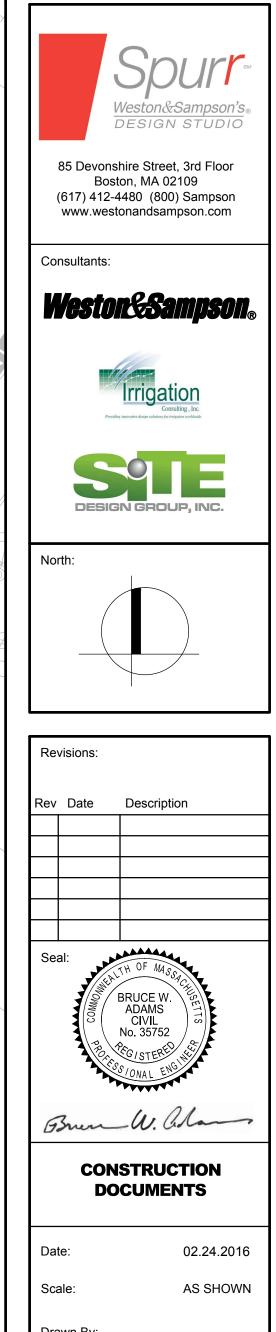

DRAINAGE PLAN

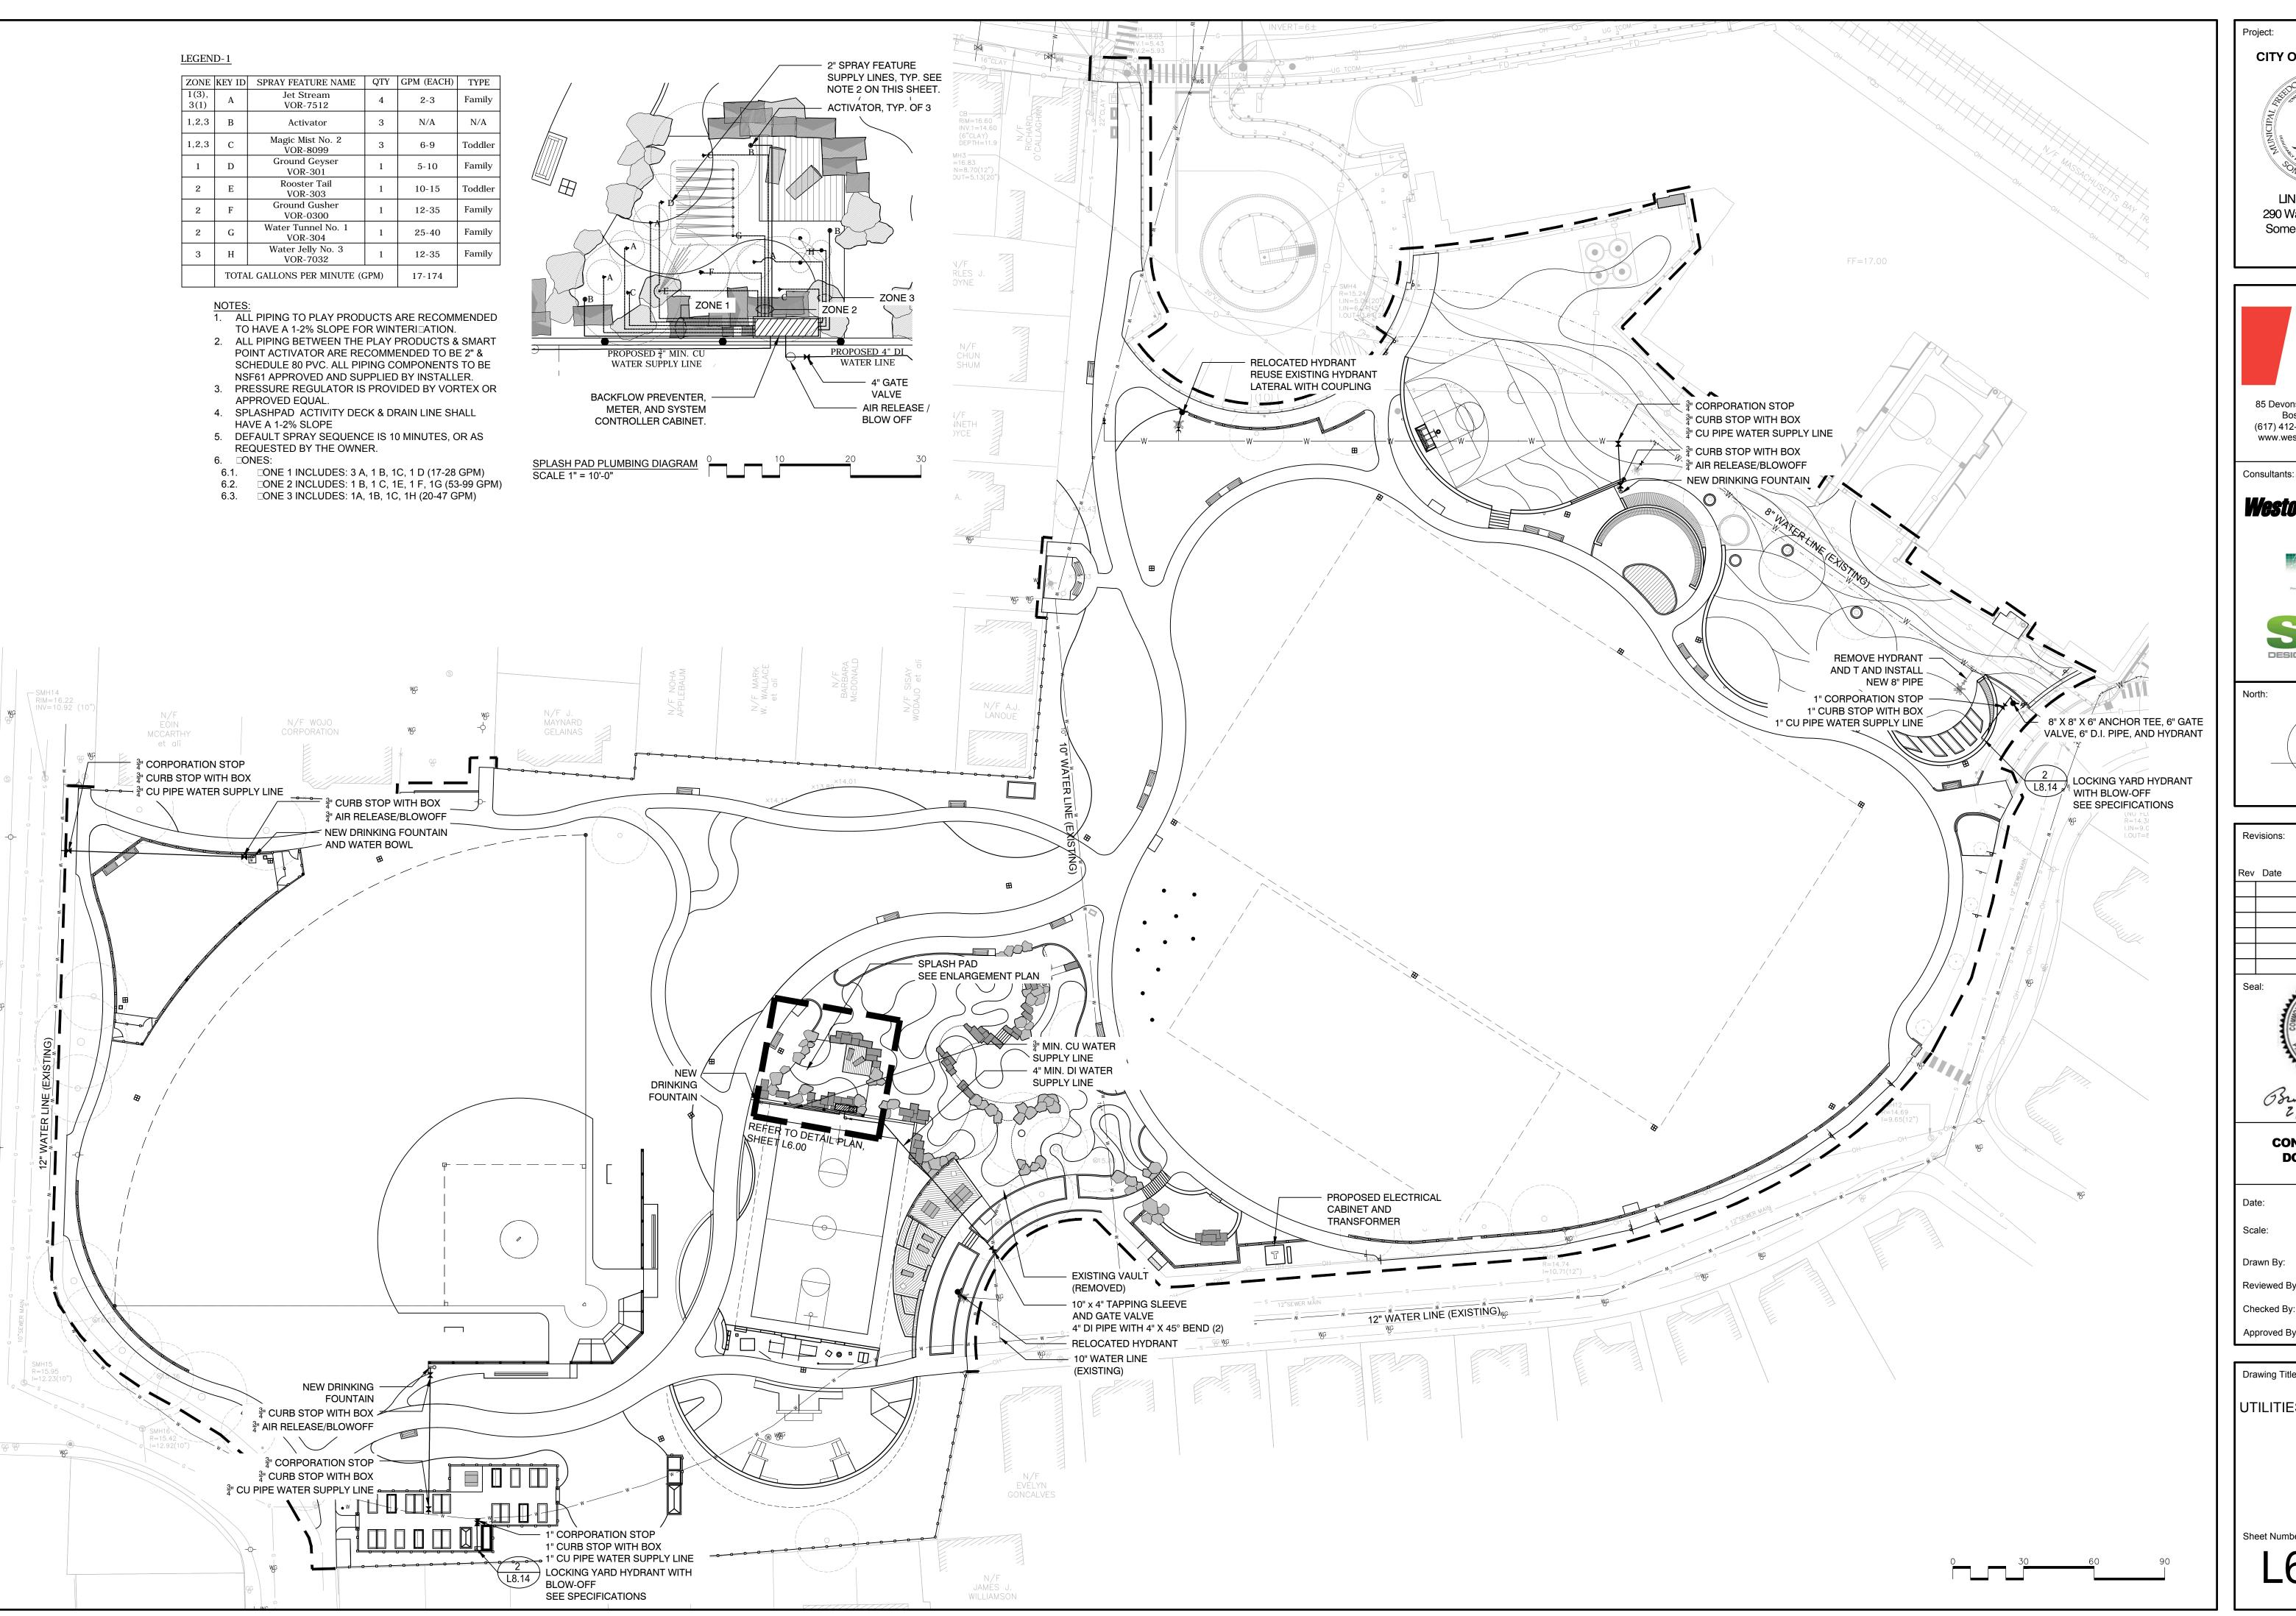

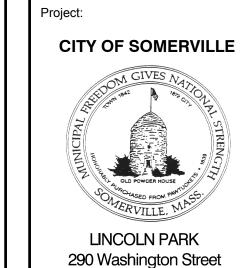




Somerville, MA 02143







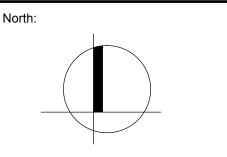

Rev	isions:	
Rev	Date	Description
Sea	al:	TH OF MASO
	1/3	BRUCE W.
	300	ADAMS CIVIL No. 35752
	1	NO. 35/52


CONSTRUCTION DOCUMENTS


Date:	02.24.2016
Scale:	AS SHOWN
Drawn By:	CCC/EJA/M
Reviewed By:	ВМК
Checked By:	
Approved By:	CFR

Drawing Title:

UTILITIES PLAN

Sheet Number:

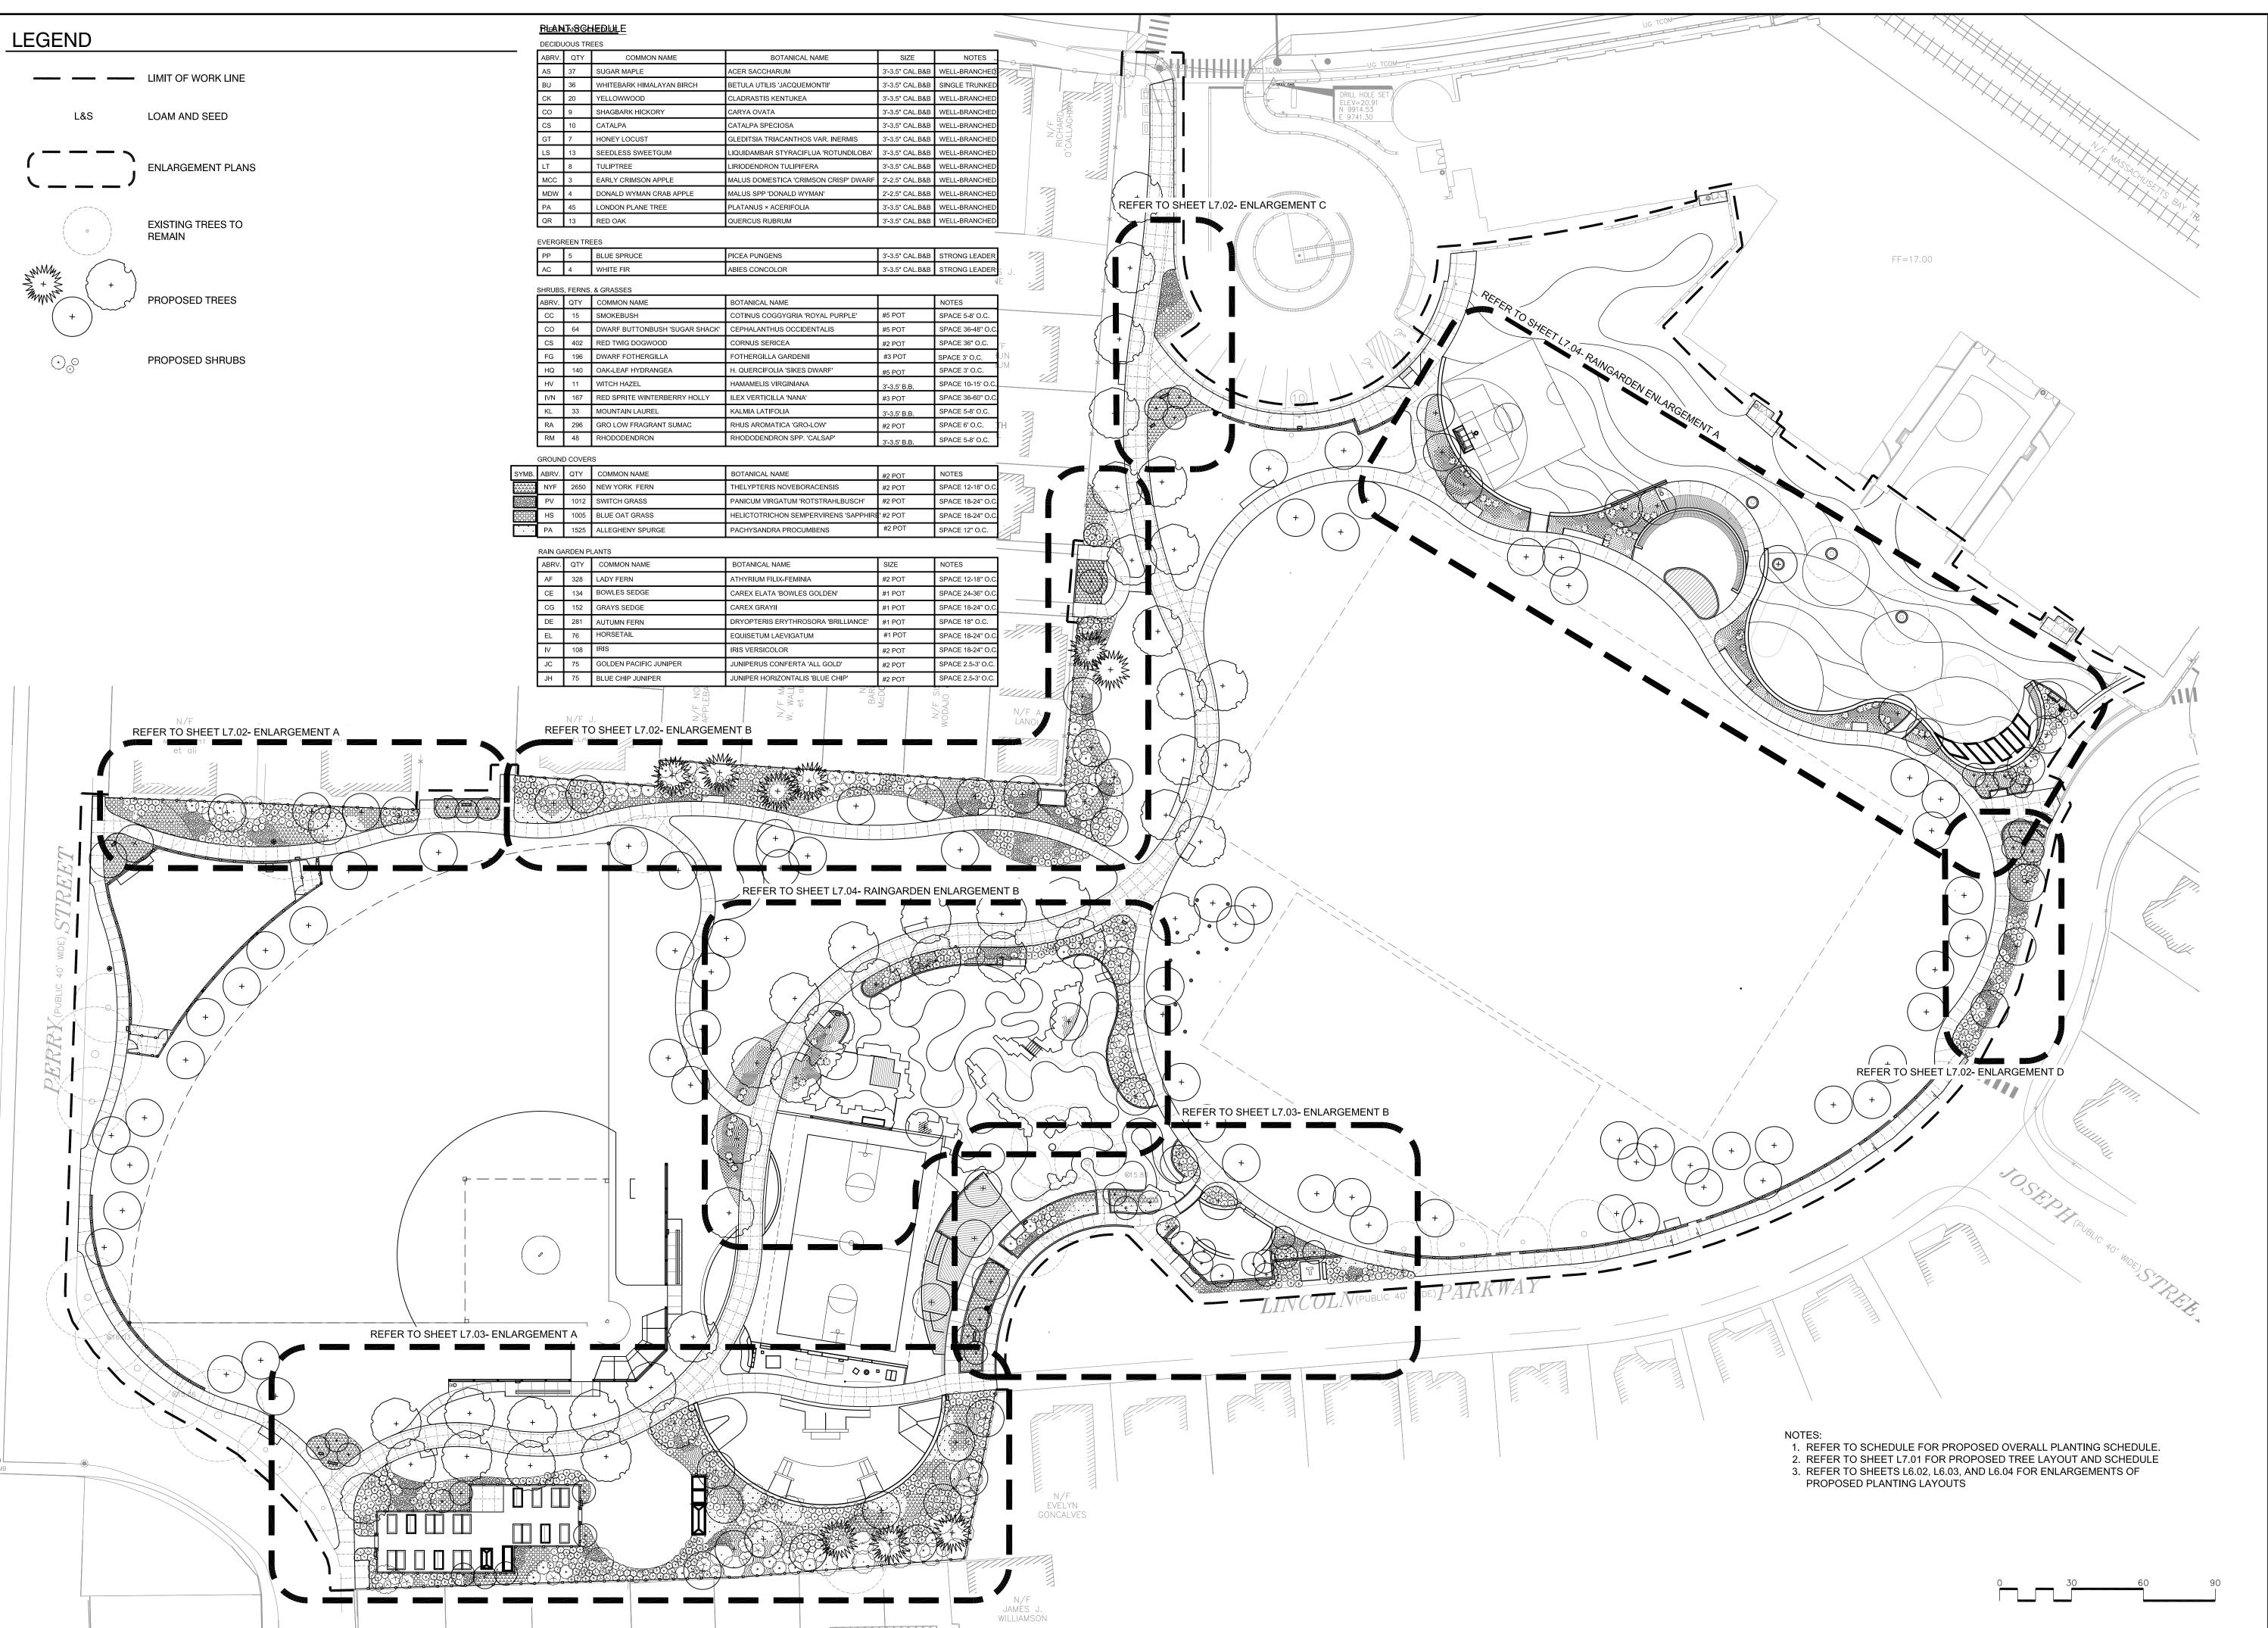

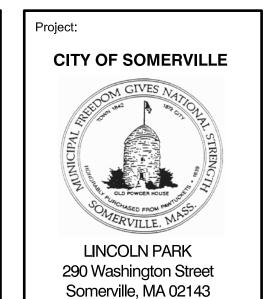




Consultants:







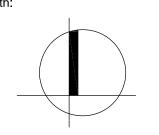

	Re	visions:	
	Rev	Date	Description
	\triangle	03/07/16	ADDENDUM #1
	Sea	al:	



CONSTRUCTION **DOCUMENTS**


02.24.2016 AS SHOWN CCC/EJA/MB Drawn By:

Checked By: Approved By:

Drawing Title:

PLANTING PLAN



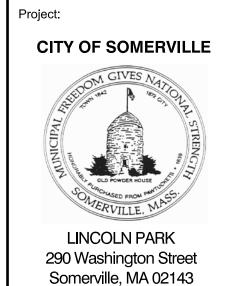




Weston&Sampson





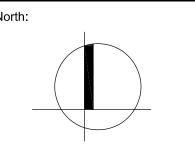

Re	visions:	
Rev	Date	Description
Â	03/07/16	ADDENDUM #1
l		





CONSTRUCTION **DOCUMENTS**

Date:	02.24.2016
Scale:	AS SHOWN
Drawn By:	CCC/EJA/MB
Reviewed By:	вмк

Checked By:

PLANTING PLAN - TREES

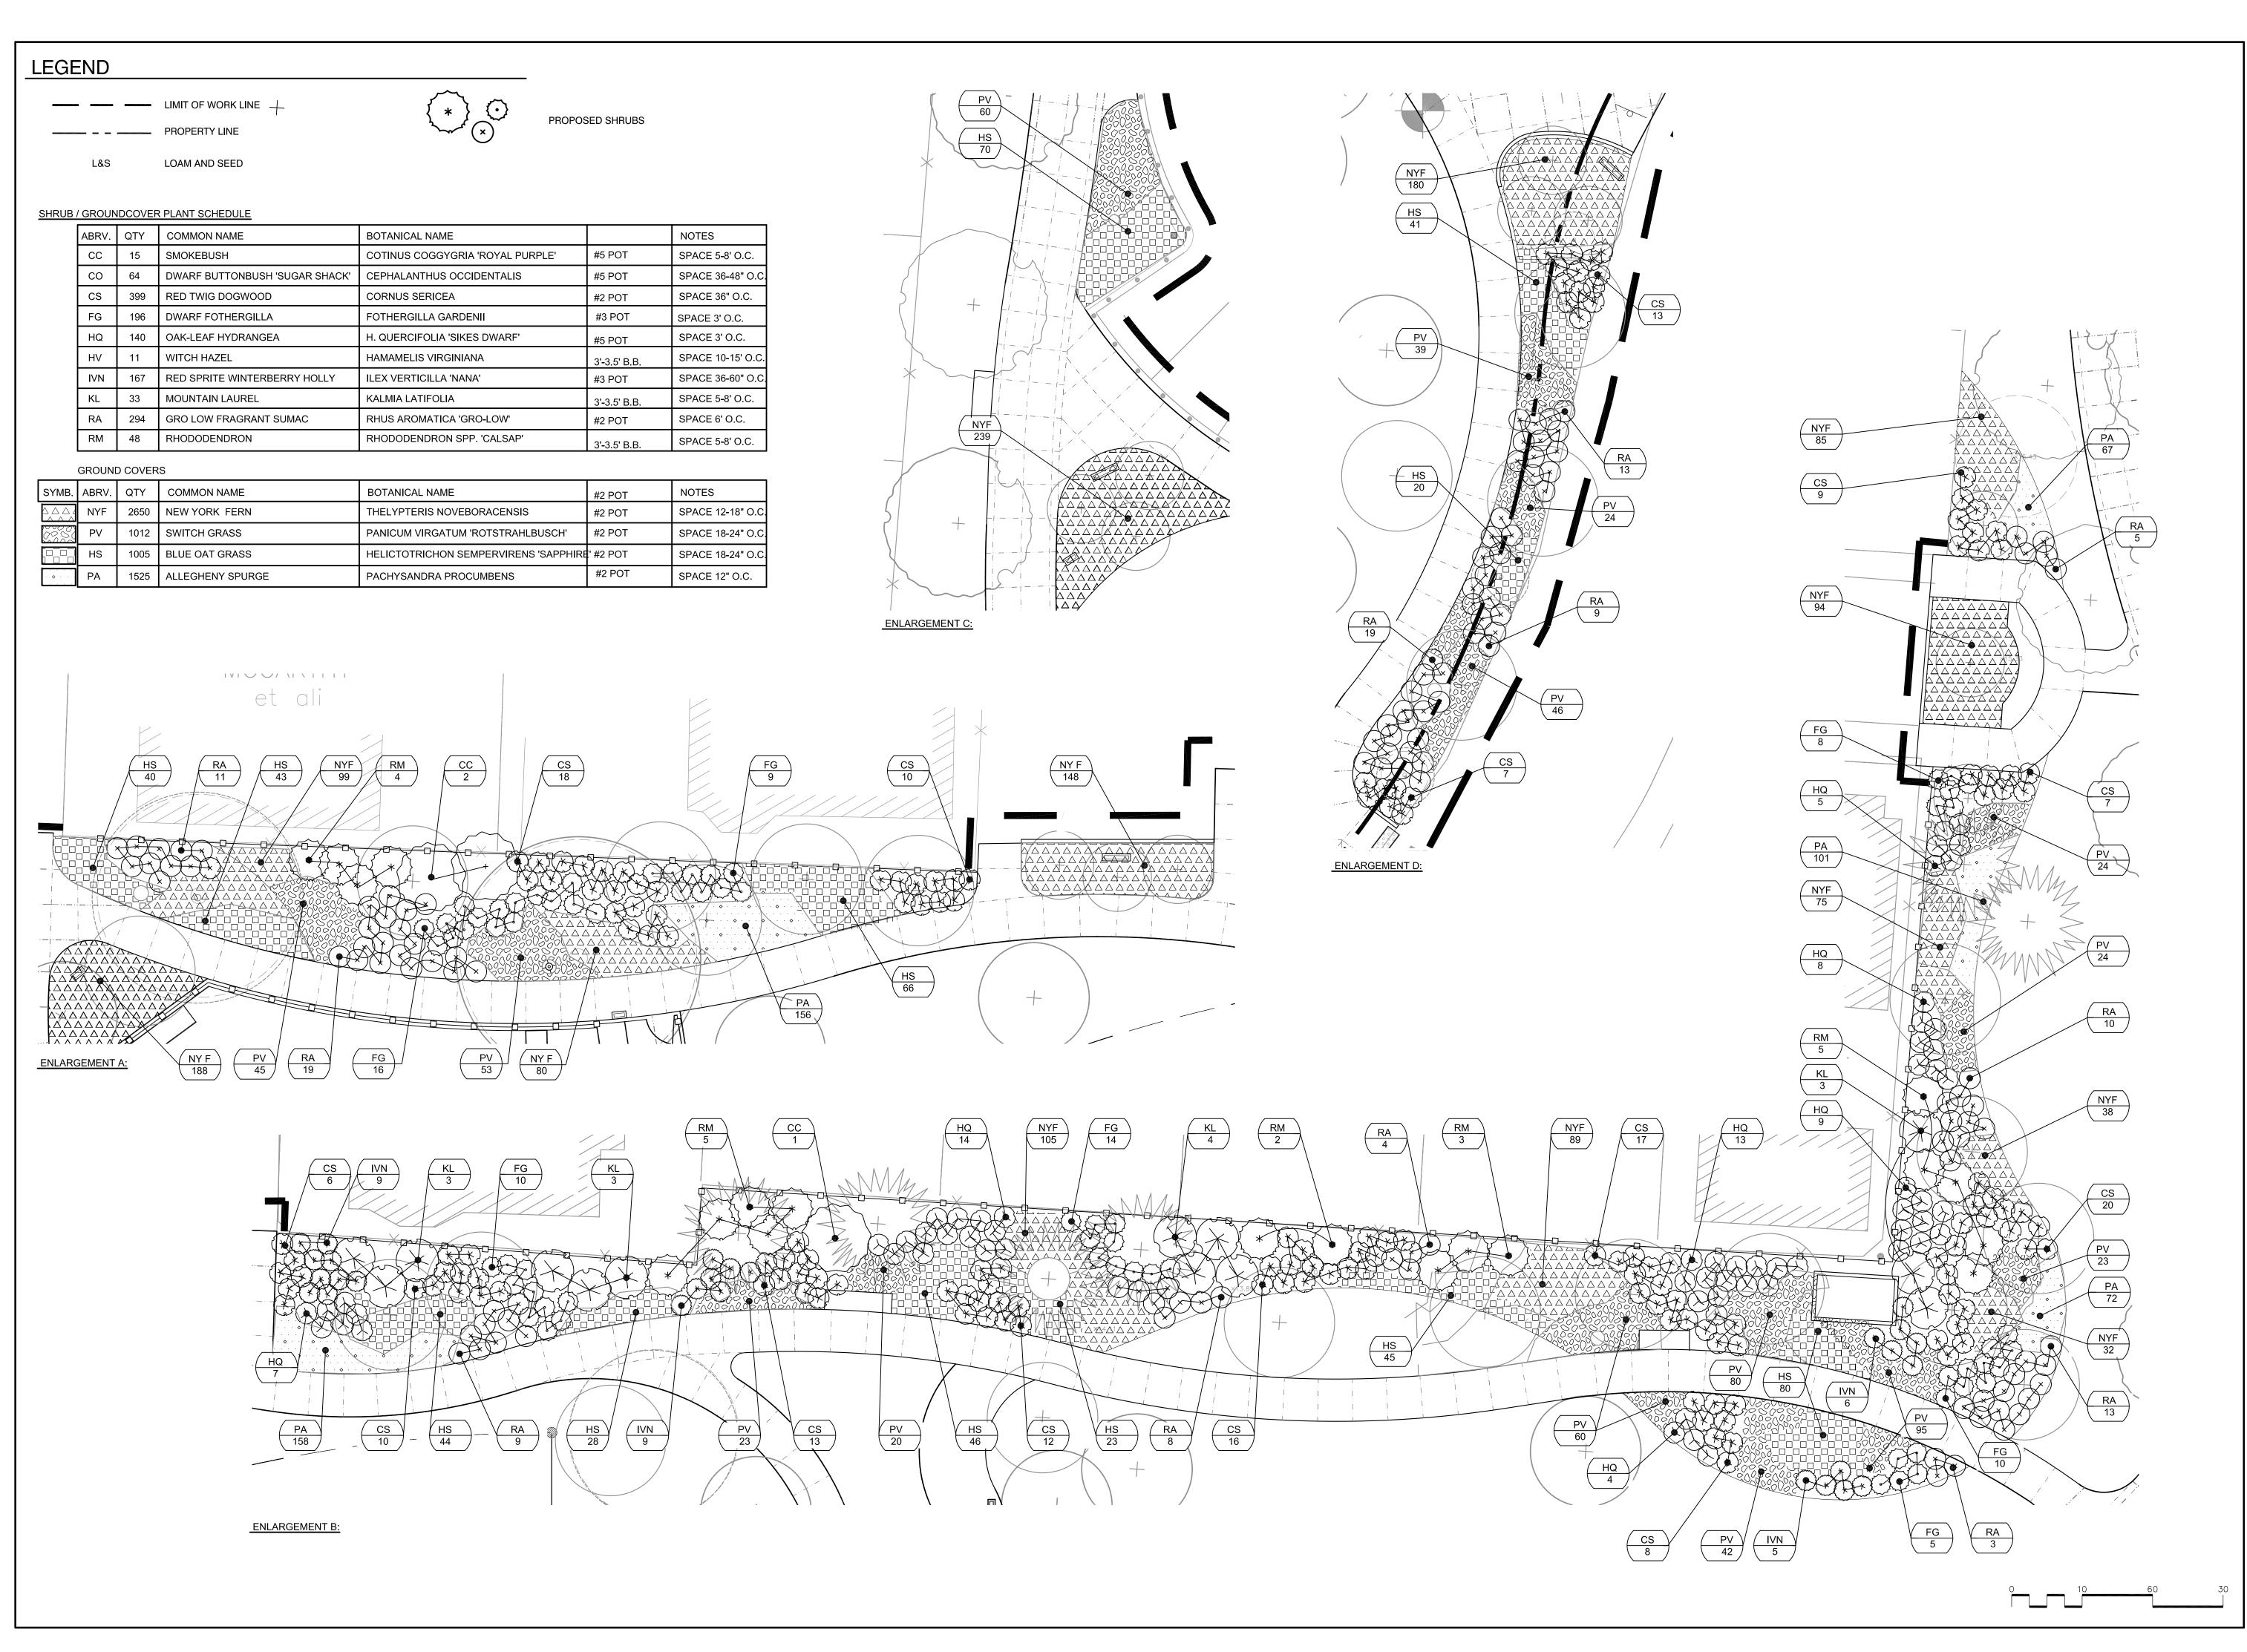

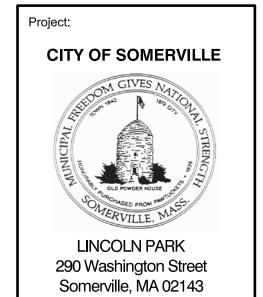




Consultants:





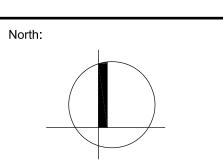

Re	visions:		
Rev	Date	Description	
Â	03/07/16	ADDENDUM #1	



CONSTRUCTION DOCUMENTS

Date: 02.24.2016

Scale: AS SHOWN

Drawn By: CCC/EJA/MBE

Reviewed By: BMK


Checked By:
Approved By:


Drawing Title:

PLANTING PLAN ENLARGEMENTS

Sheet Number:

L7.02

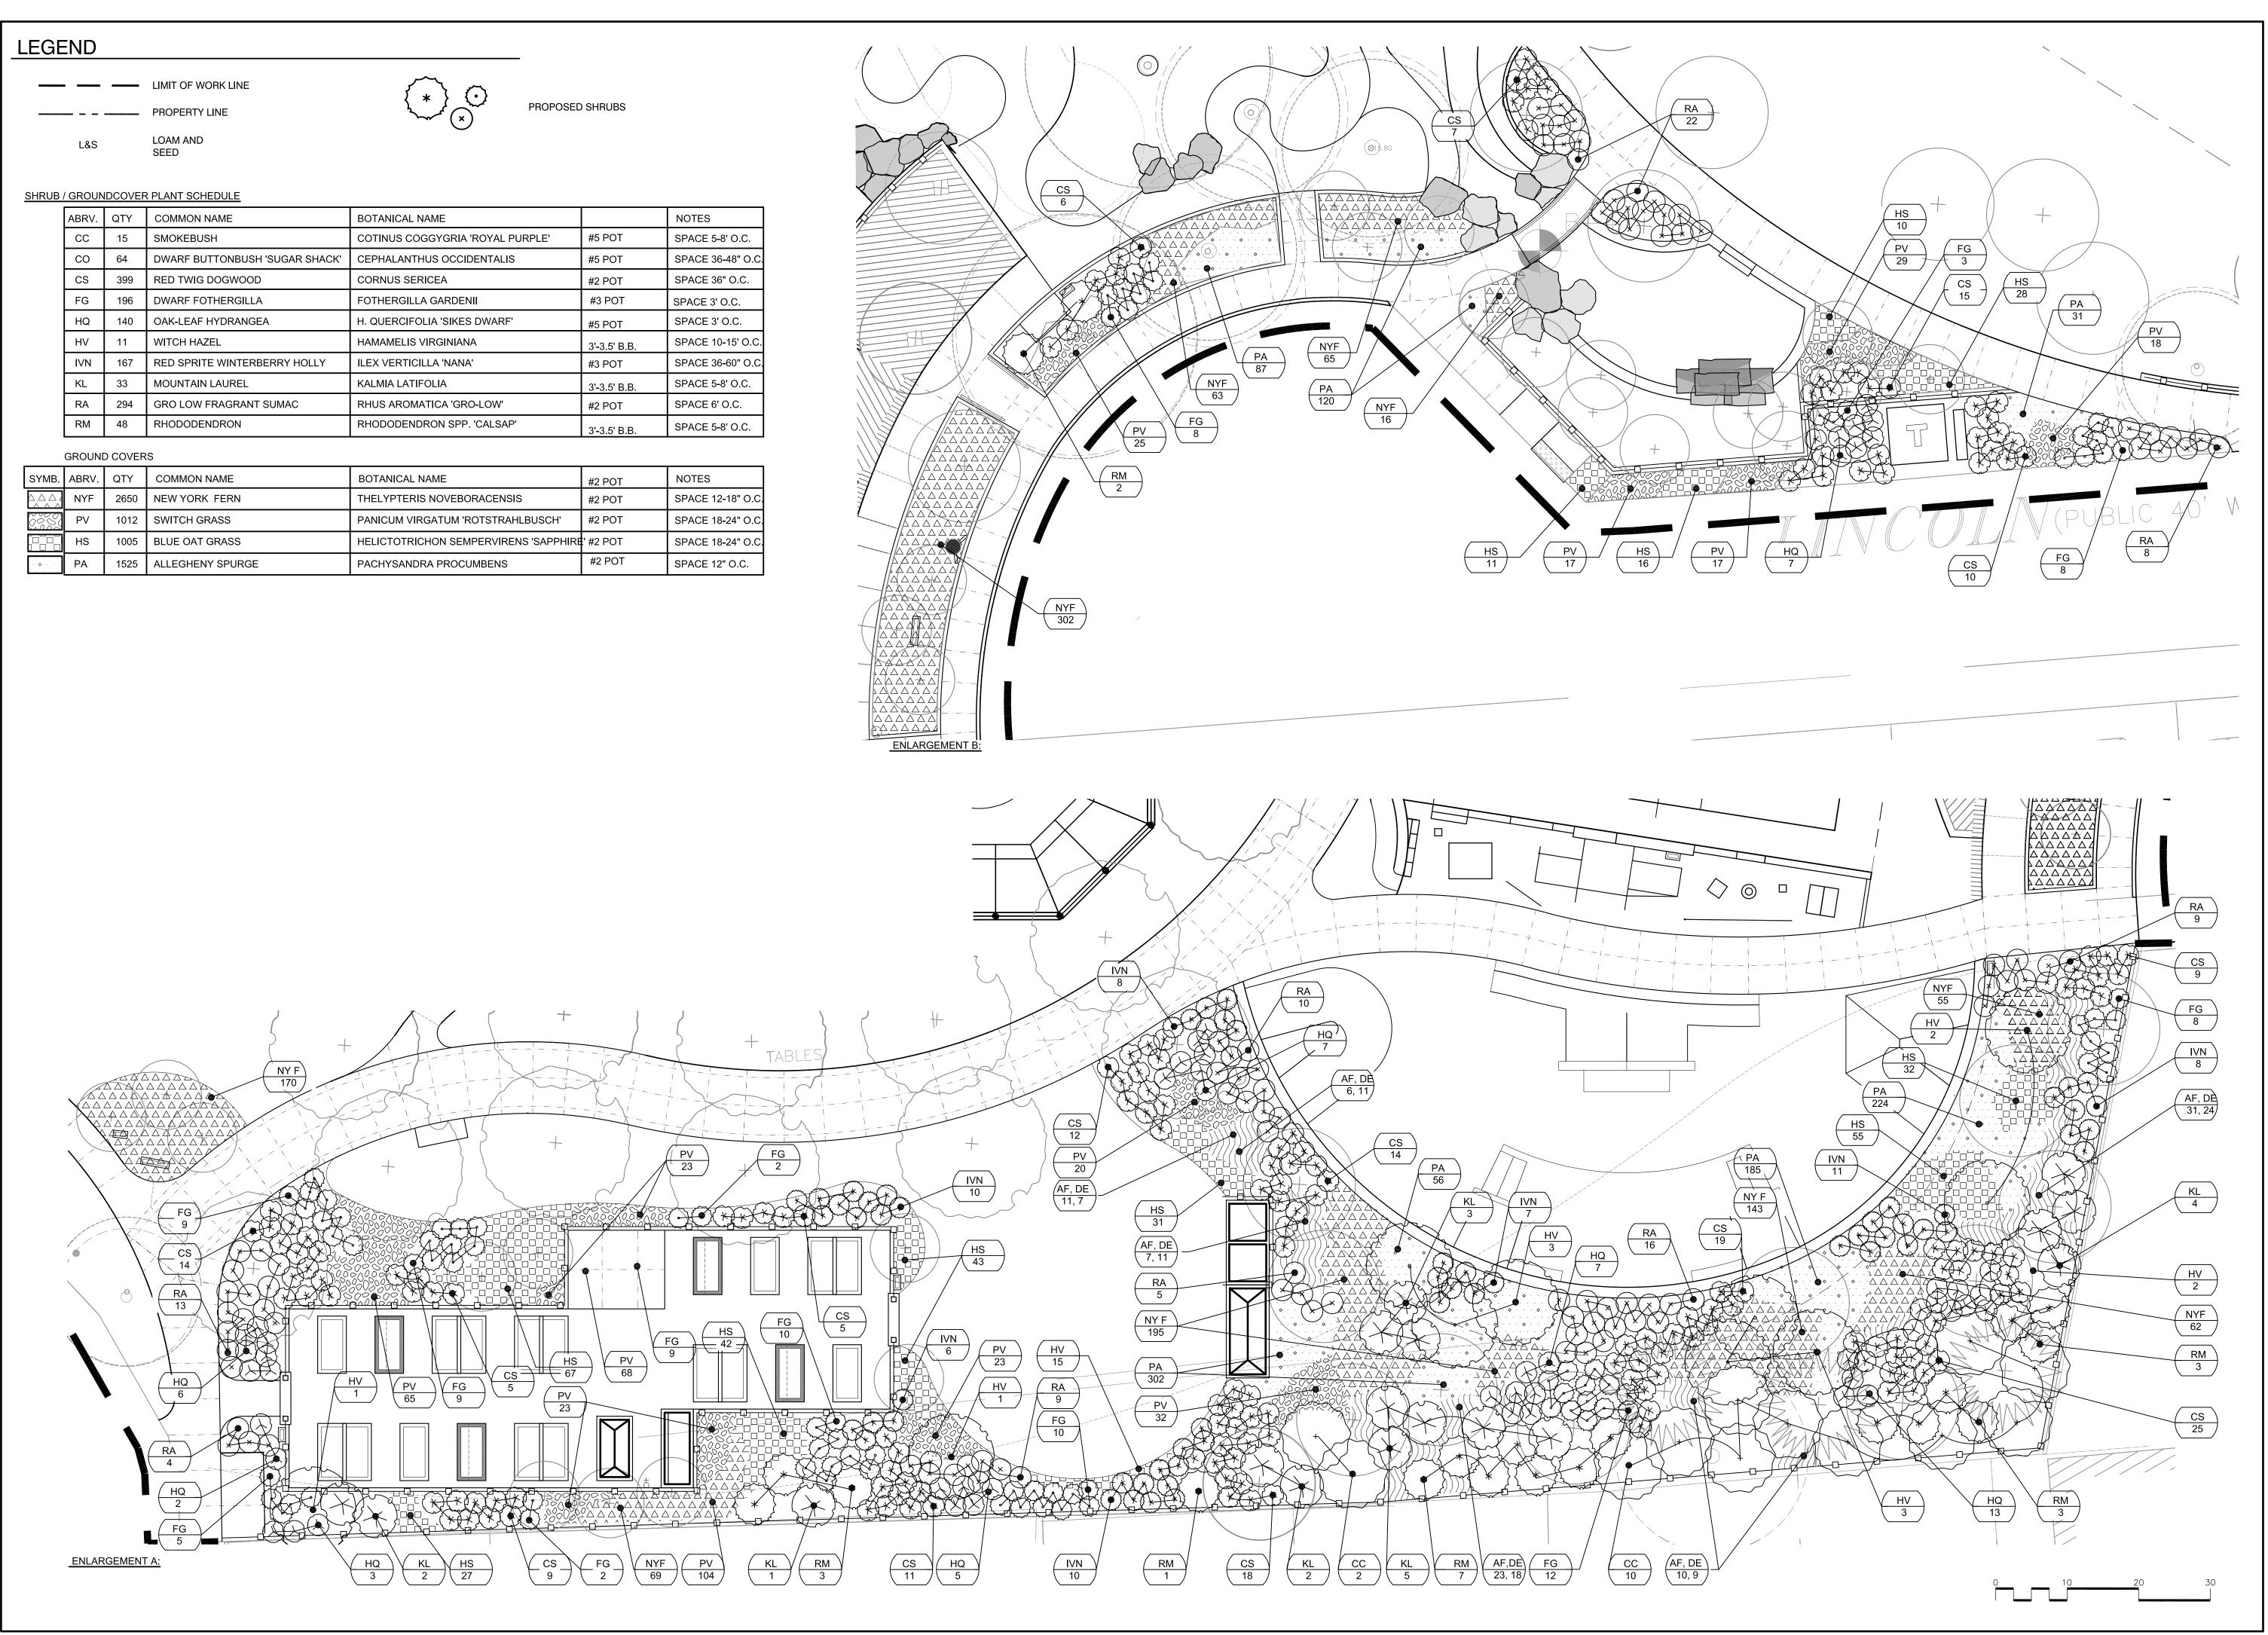

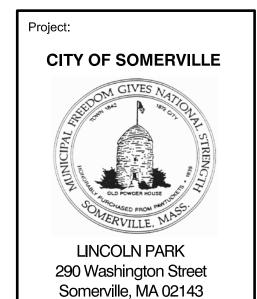



Consultants:

Weston Sampson®





North:

			1
	Re	visions:	
	Rev	Date	Description
	\triangle	03/07/16	ADDENDUM #1
	Sea	 al [.]	
	00.	ui.	
		ani a	MUSACHUSE VN F SZONA)
		* AFE	

CONSTRUCTION DOCUMENTS

Date: 02.24.2016

Scale: AS SHOWN


Drawn By: CCC/EJA/MBE


Reviewed By: BMK

Checked By:

PLANTING PLAN
ENLARGEMENTS

Sheet Number: L7.03

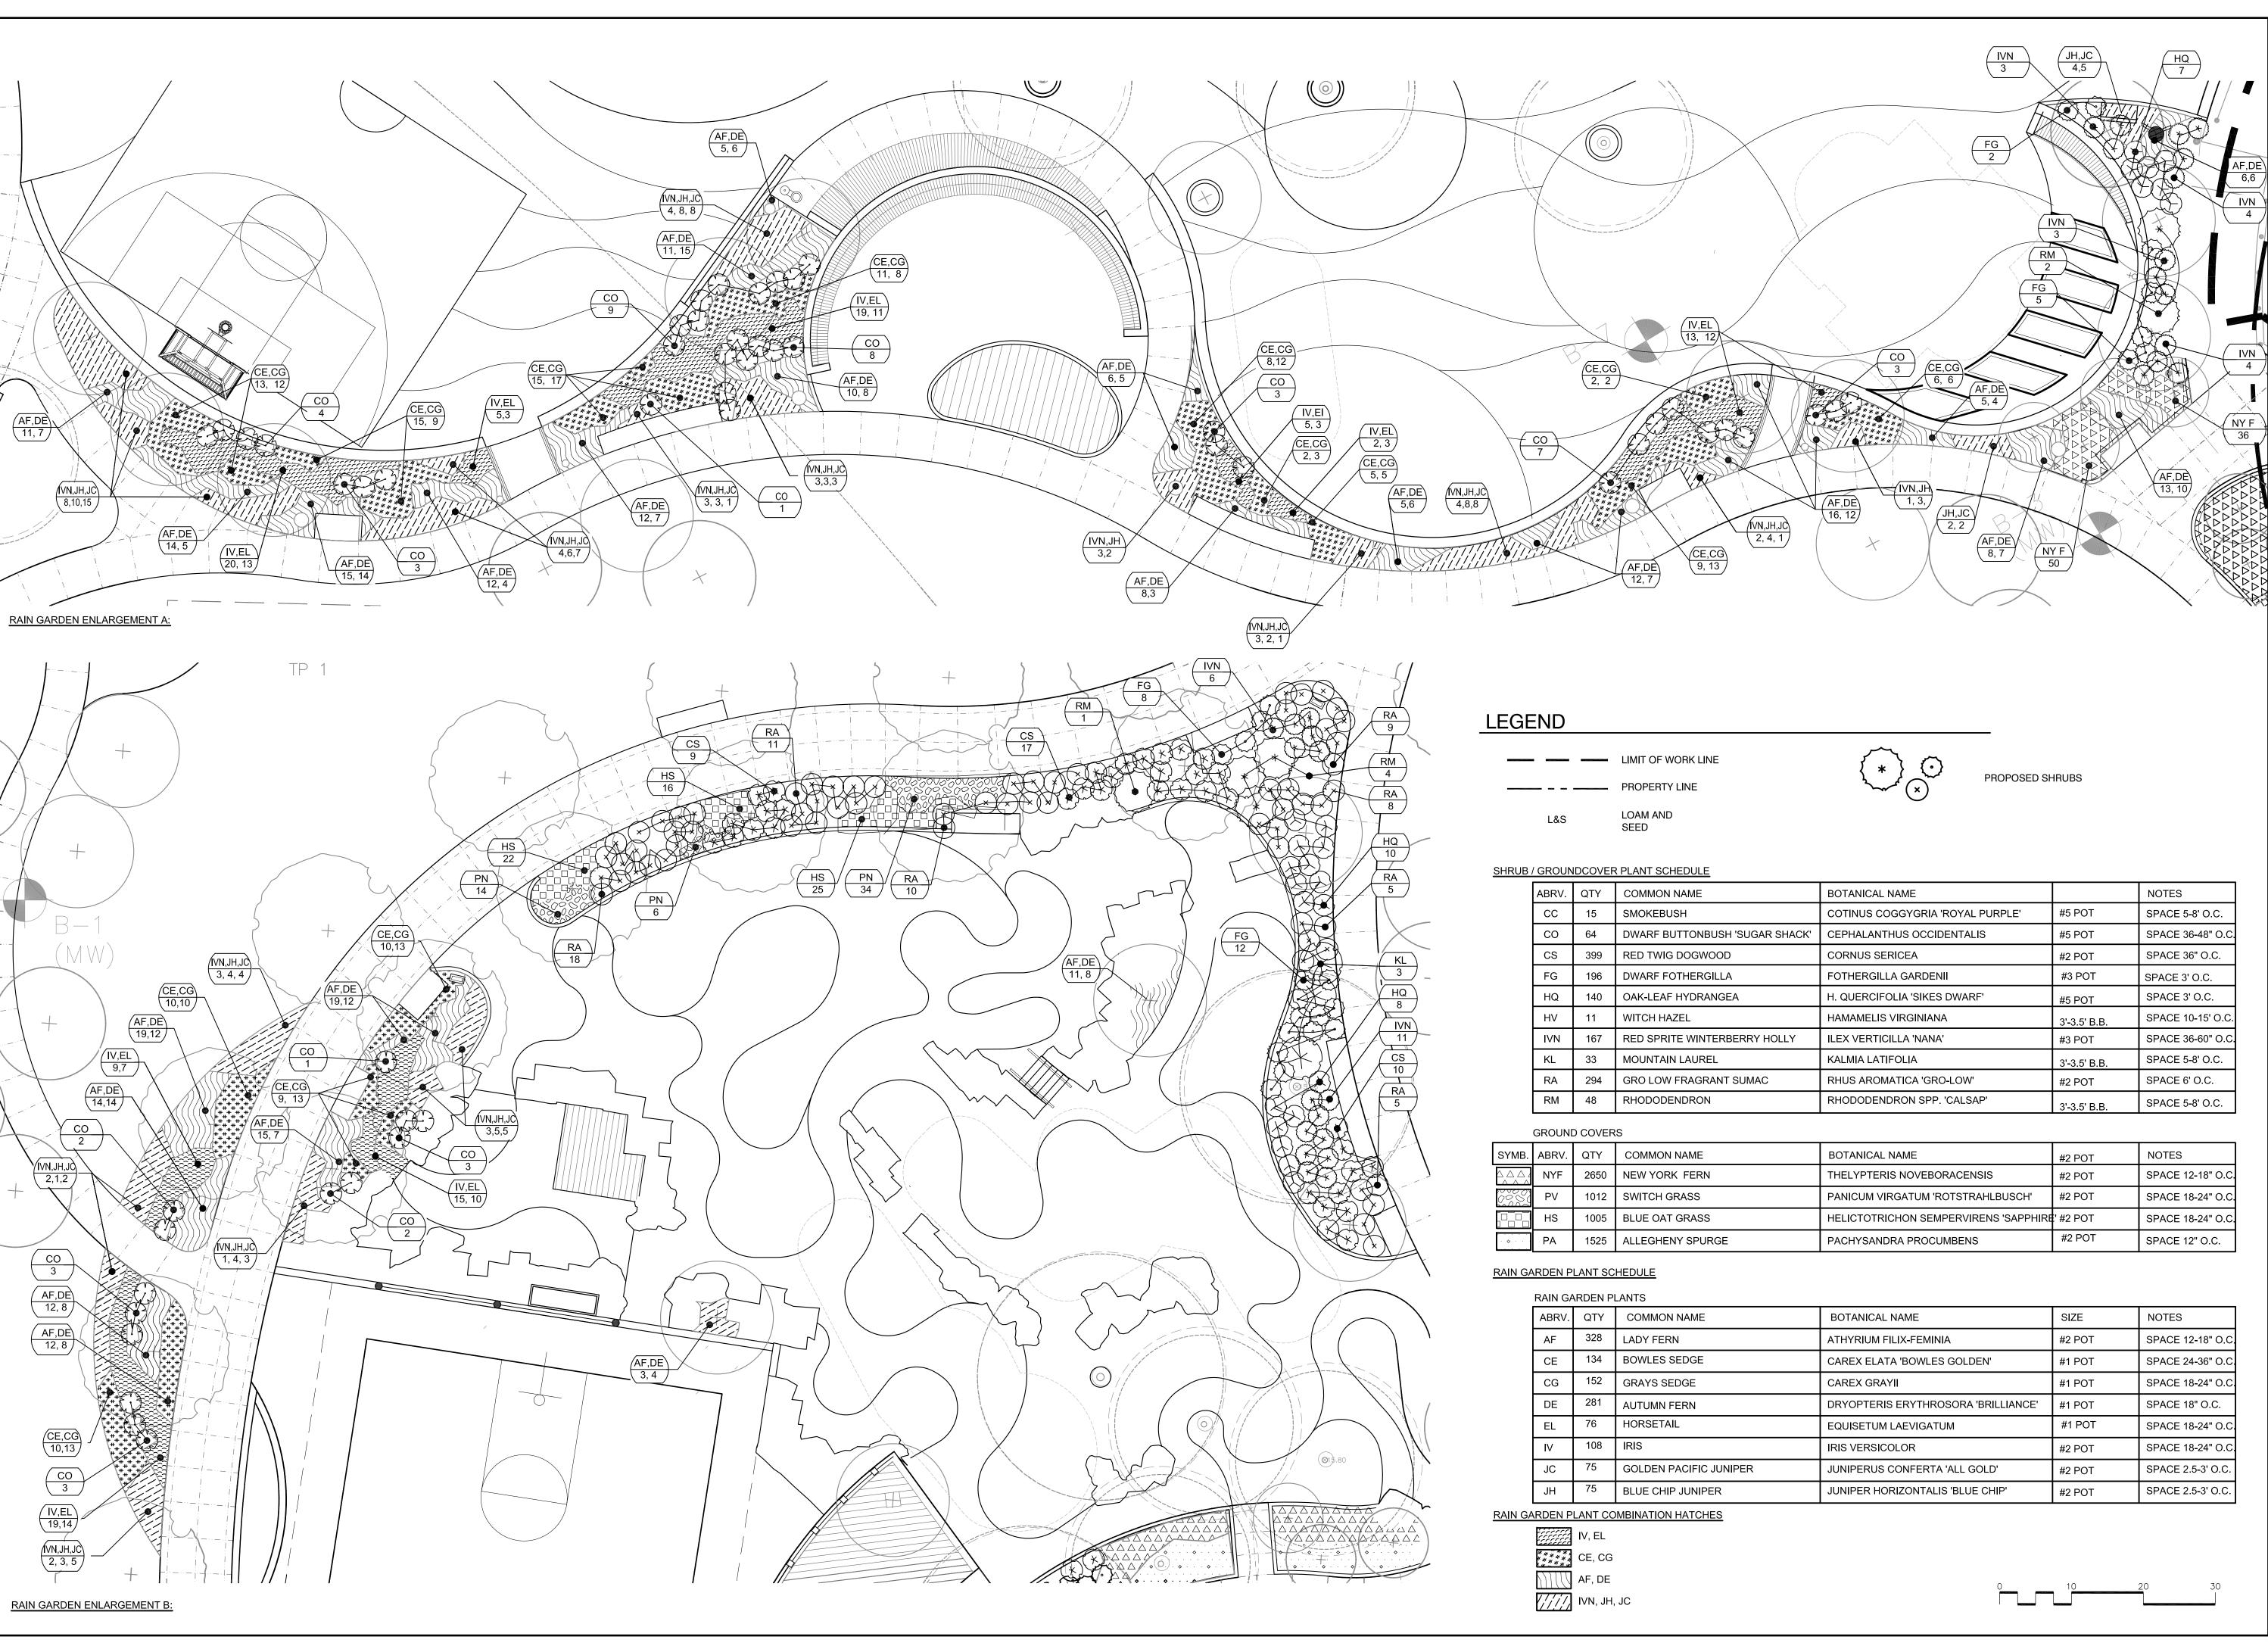

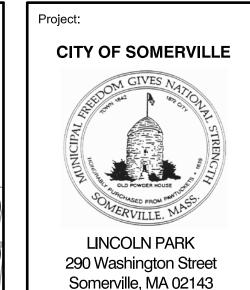




Consultants: Weston&Sampson





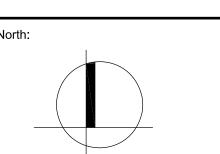

_			
Re	visions:		
Rev	Date	Description	
\triangle	03/07/16	ADDENDUM #1	
-			



CONSTRUCTION DOCUMENTS

Date: 02.24.2016 Scale: AS SHOWN CCC/EJA/MBE Drawn By:

Reviewed By:

Checked By: CFR Approved By:

Drawing Title:

PLANTING PLAN ENLARGEMENTS